 


A PORTION OF THE SE 1/4 OF SECTION 23, TWP. 26 N., RGE. 1 E., WM



REVISIONS		
NO.	DESCRIPTION/DATE	BY




ESM CONSULTING ENGINEERS, LLC
 33400 8th Ave S, Suite 205
 Federal Way, WA 98003
 www.esmcivil.com
 Civil Engineering | Land Surveying | Project Management | Landscape Architecture
 (206) 838-6113
 (206) 838-6113
 (206) 838-6113



LEGEND

	SANITARY SEWER MAIN
	WATER MAIN
	STORM DRAIN LINE
	WATER VALVE
	FIRE HYDRANT
	CATCH BASIN, TYPE 1
	SANITARY SEWER MANHOLE
	EXISTING CONTOURS
	PROPOSED CONTOURS
	SIDEWALK
	ASPHALT
	CRITICAL AREA BUFFER
	WETLAND

NOTES:
 1. SEE SHEET PP-14 FOR STREET CROSS SECTIONS.

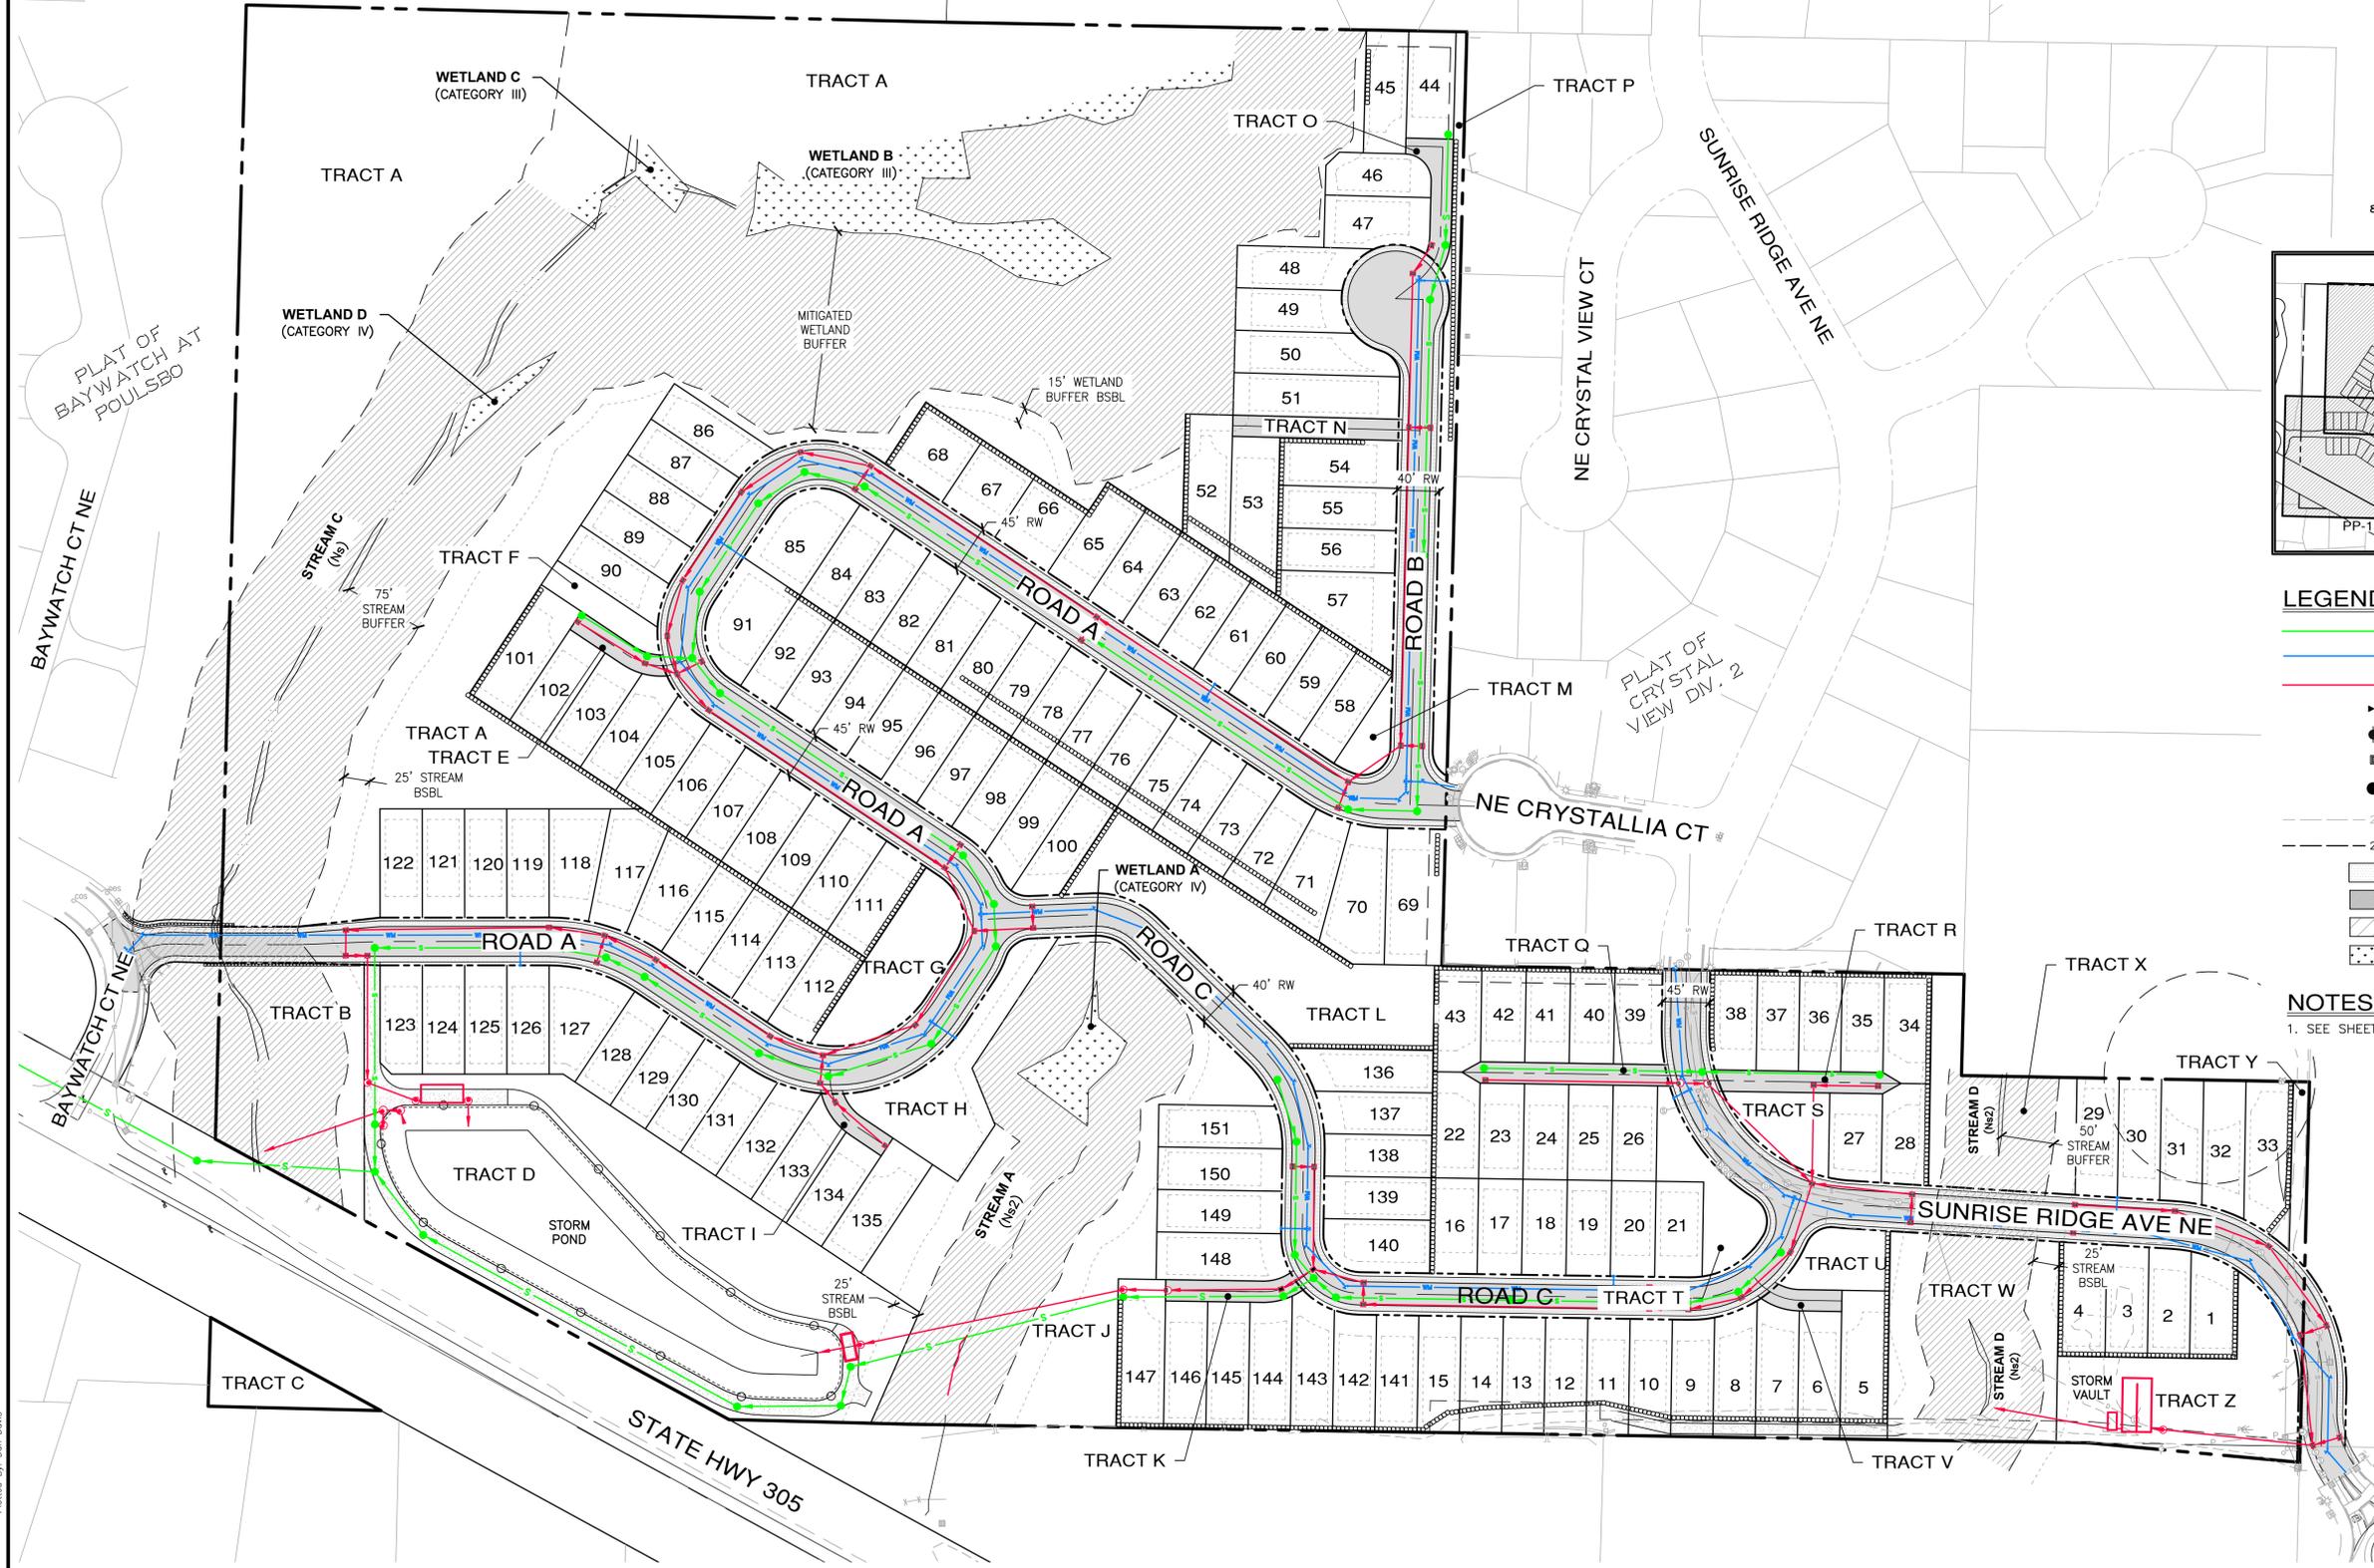


File: \\mms\ENGR\ESM-JOBES\2090\04\022\PP-plot\PlotA\PP-13.dwg
 Plotted: 6/20/2025 3:56 PM
 Plotted By: Don Davis


MONTEBANC MANAGEMENT, LLC
PINNACLE AT LIBERTY BAY SUBDIVISION
 OVERALL ROAD & UTILITY PLAN
 WASHINGTON
 CITY OF POULSBORO

JOB NO.:	2090-004-022
DWG. NAME:	PP-13
DESIGNED BY:	
DRAWN BY:	
CHECKED BY:	
DATE:	6/20/2025
DATE OF PRINT:	


A PORTION OF THE SE 1/4 OF SECTION 23, TWP. 26 N., RGE. 1 E., WM

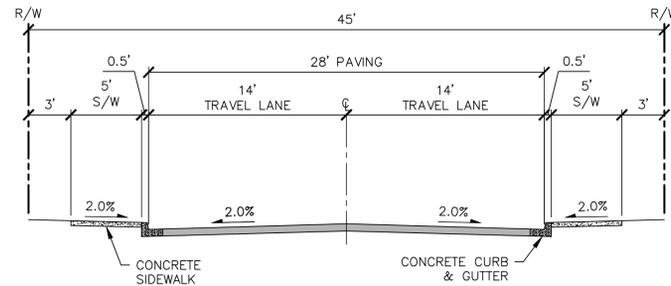


TYPICAL ROAD SECTION
ROAD A
SCALE: 1"=6'

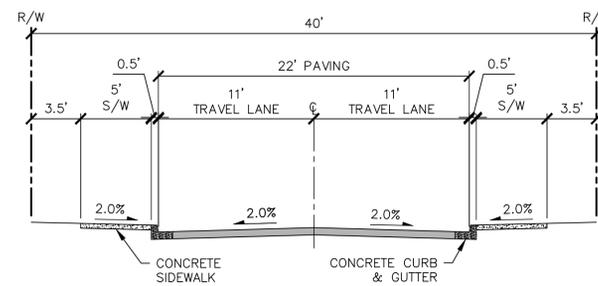


TYPICAL ROAD SECTION
ROAD B AND C
SCALE: 1"=6'

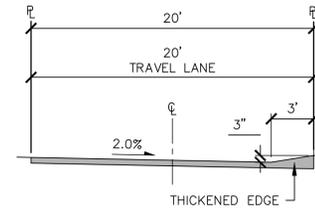


SHARED ACCESS
OPTION 1
SCALE: 1"=6'

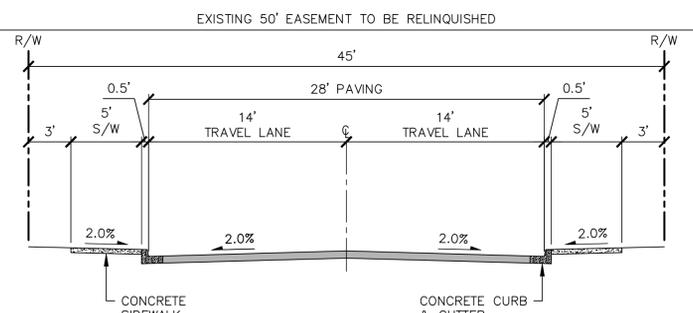

TYPICAL ROAD SECTION
SUNRISE RIDGE AVE NE
SCALE: 1"=6'

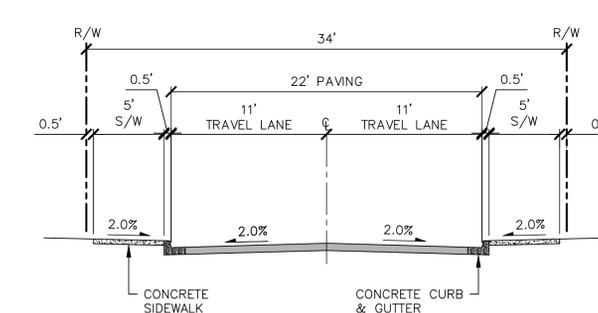



TYPICAL ROAD SECTION
ROAD A STREAM CROSSING
SCALE: 1"=6'

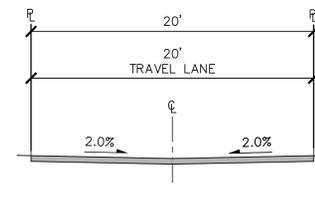


SHARED ACCESS
OPTION 2
SCALE: 1"=6'

LEGEND

 - SANITARY SEWER MAIN
- WATER MAIN
- STORM DRAIN LINE
- ⊕ WATER VALVE
- ⊕ FIRE HYDRANT
- ⊕ CATCH BASIN, TYPE 1
- SANITARY SEWER MANHOLE
- - - 200 EXISTING CONTOURS
- - - 200 PROPOSED CONTOURS
- ▨ SIDEWALK
- ▨ ASPHALT
- ▨ CRITICAL AREA BUFFER
- ▨ WETLAND

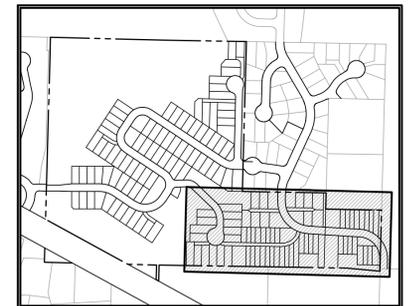

KEY MAP

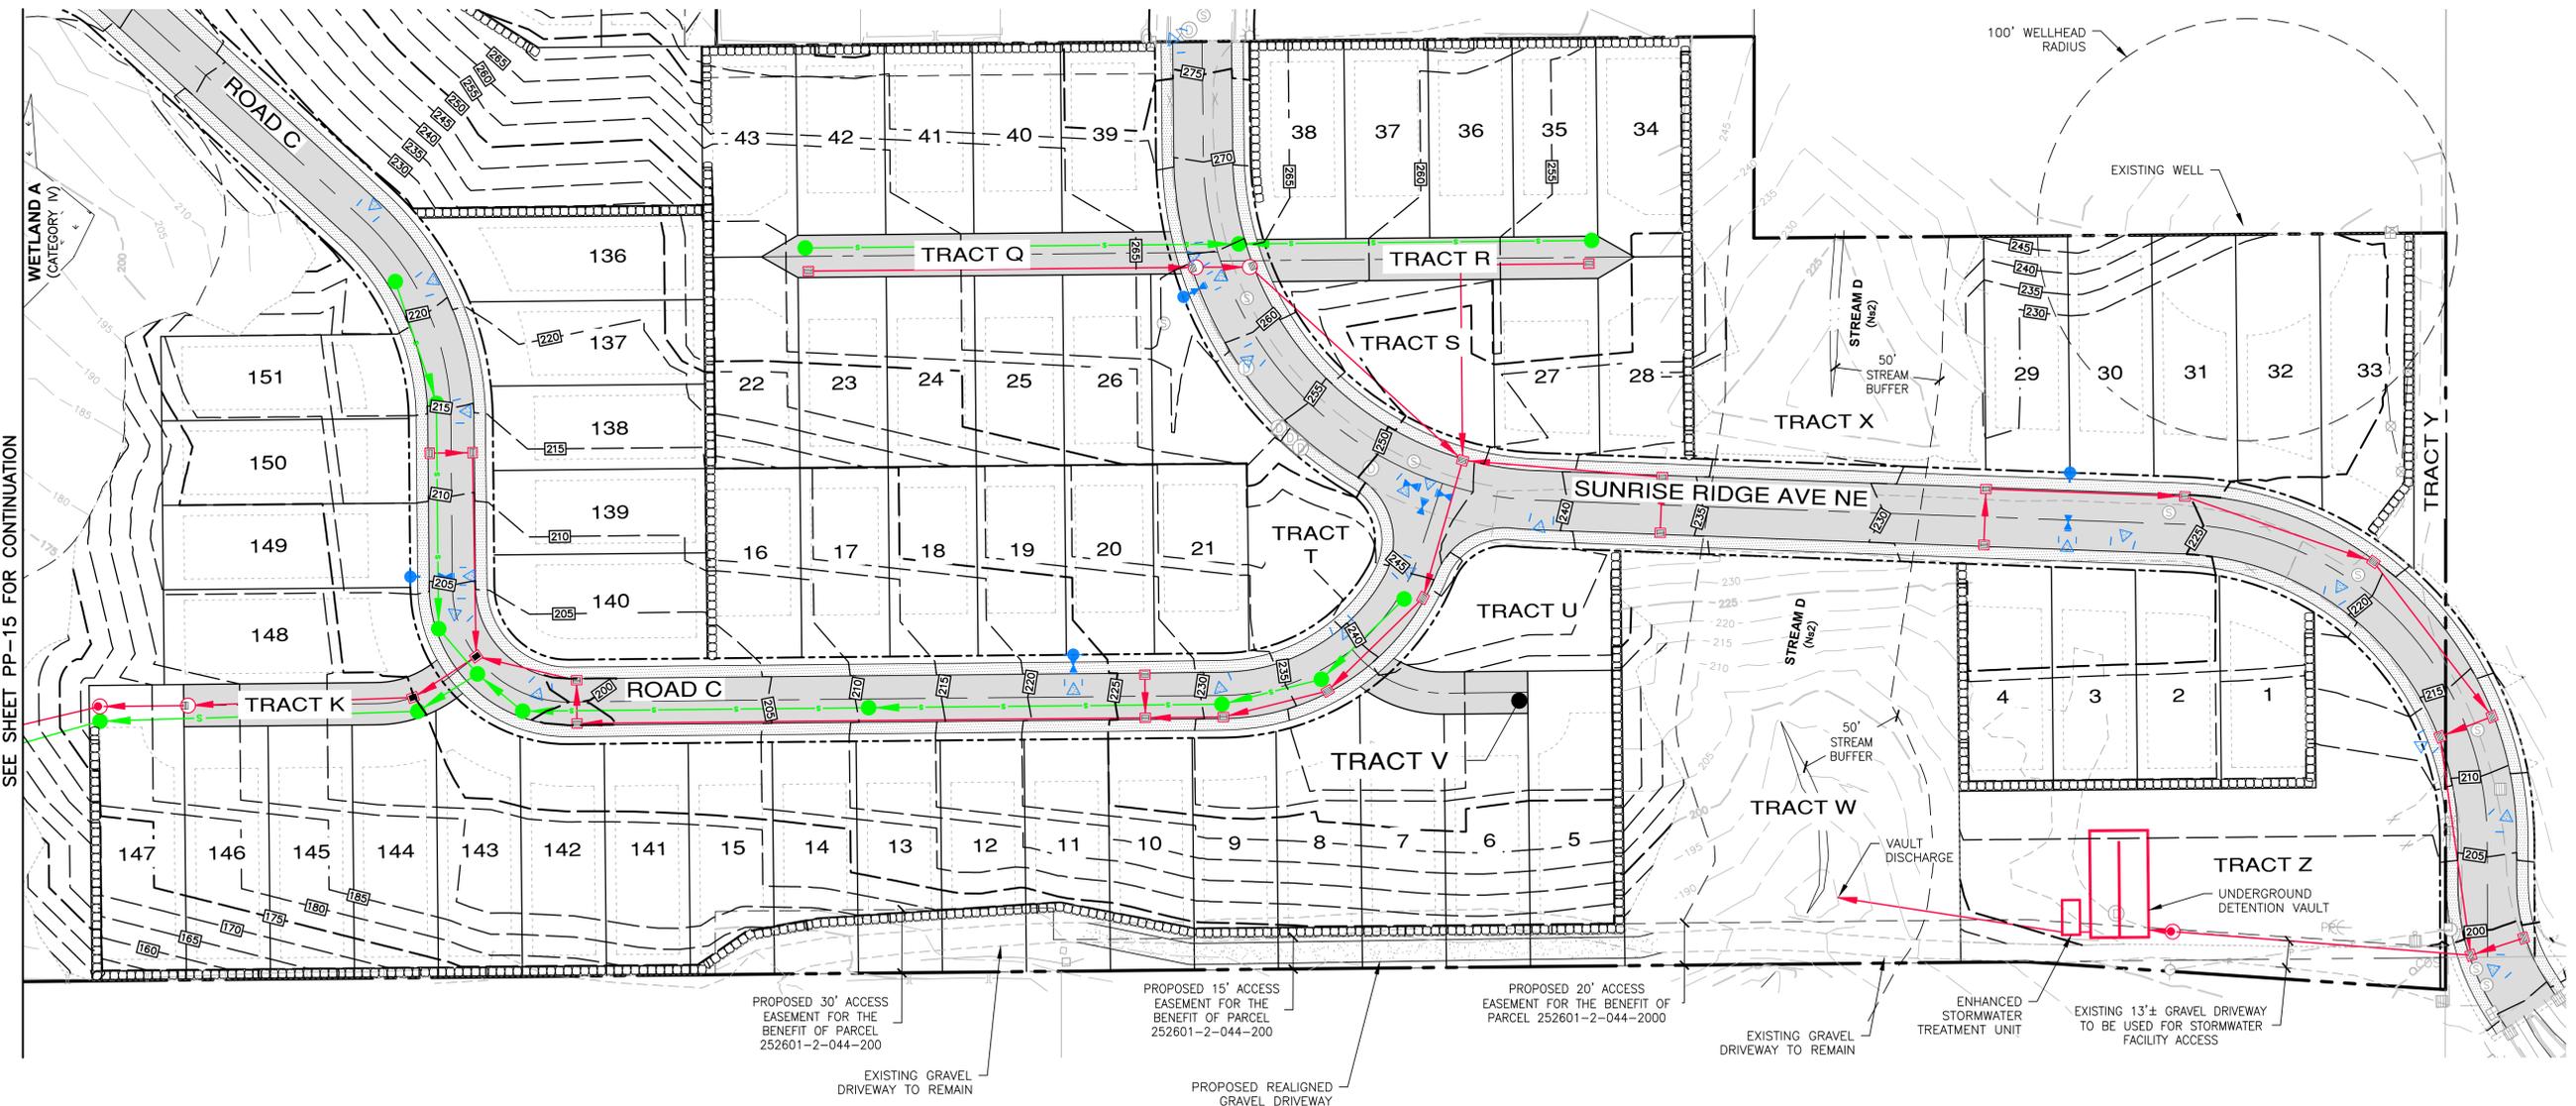

SEE SHEET PP-15 FOR CONTINUATION

File: \\wmm\ENGR\ESM-JOBES\2090\04\1022\PP-14.dwg
Plotted: 6/20/2025 3:48 PM
Plotted By: Brandon Loucks

PROPOSED 30' ACCESS
EASEMENT FOR THE
BENEFIT OF PARCEL
252601-2-044-200

EXISTING GRAVEL
DRIVEWAY TO REMAIN

PROPOSED 15' ACCESS
EASEMENT FOR THE
BENEFIT OF PARCEL
252601-2-044-200

PROPOSED REALIGNED
GRAVEL DRIVEWAY

PROPOSED 20' ACCESS
EASEMENT FOR THE BENEFIT OF
PARCEL 252601-2-044-2000

EXISTING GRAVEL
DRIVEWAY TO REMAIN

ENHANCED
STORMWATER
TREATMENT UNIT

EXISTING 13'± GRAVEL DRIVEWAY
TO BE USED FOR STORMWATER
FACILITY ACCESS

REVISIONS		
NO.	DESCRIPTION/DATE	BY



ESM CONSULTING ENGINEERS, LLC
33400 8th Ave S, Suite 205
Federal Way, WA 98003
www.esmcivil.com
Civil Engineering
Public Works


MONTEBANC MANAGEMENT, LLC
Land Planning
Project Management
Landscape Architecture

MONTEBANC MANAGEMENT, LLC
Pinnacle at Liberty Bay Subdivision
Preliminary Road & Utility Plan
Washington
City of Poulsbo

JOB NO.: 2090-004-022
DWG. NAME: PP-14
DESIGNED BY:
DRAWN BY:
CHECKED BY:
DATE: 6/20/2025
DATE OF PRINT:
PP-14
14 OF 26 SHEETS



SCALE: 1" = 40'
CONTOUR INTERVAL = 5'

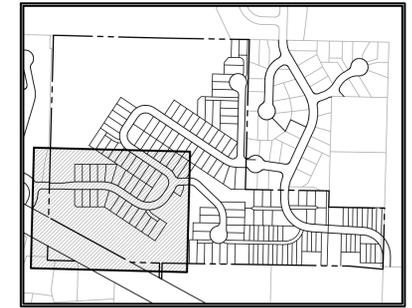

KEY MAP

LEGEND

- SANITARY SEWER MAIN
- WATER MAIN
- STORM DRAIN LINE
- WATER VALVE
- FIRE HYDRANT
- CATCH BASIN, TYPE 1
- SANITARY SEWER MANHOLE
- EXISTING CONTOURS
- PROPOSED CONTOURS
- SIDEWALK
- ASPHALT
- CRITICAL AREA BUFFER
- WETLAND


NOTES:

1. SEE SHEET PP-14 FOR STREET CROSS SECTIONS.

POND VOLUME


MODELED VOLUME: 280,526 CF (6.440 AC-FT)
PROPOSED VOLUME: 373,261 CF (8.569 AC-FT)

SEE SHEET PP-14 FOR CONTINUATION

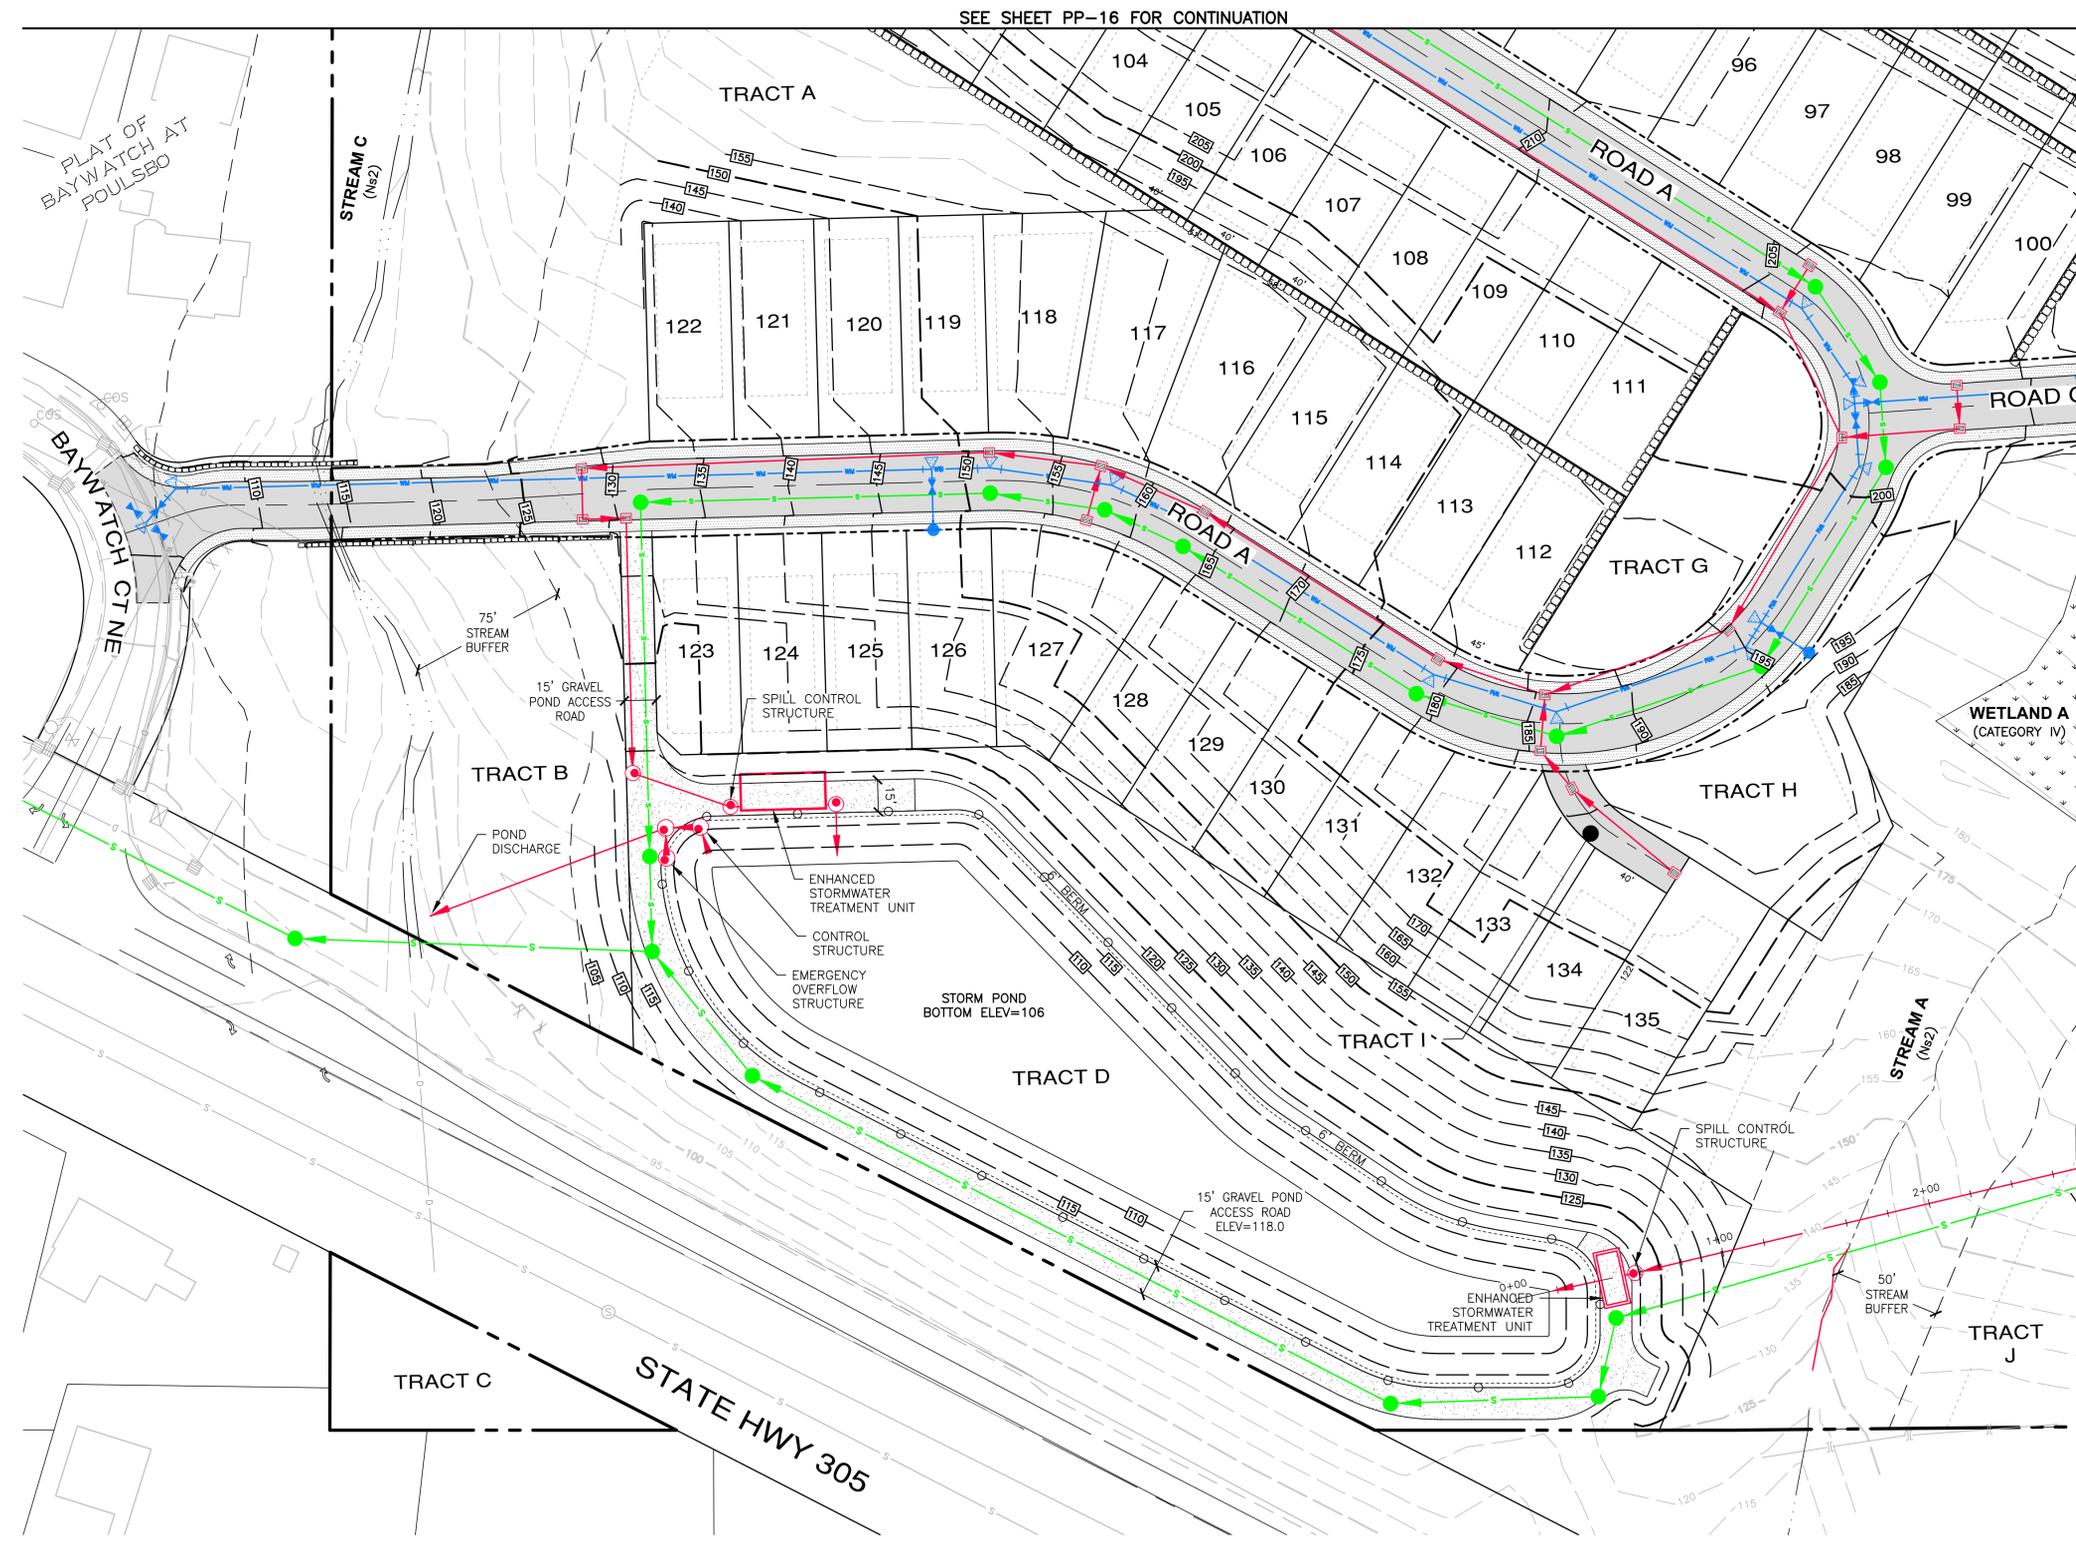

SEE SHEET PP-16 FOR CONTINUATION

REVISIONS		
NO.	DESCRIPTION/DATE	BY

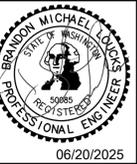


MONTEBANC MANAGEMENT, LLC
CONSULTING ENGINEERS, LLC
33400 8th Ave S, Suite 205
Federal Way, WA 98003
www.esmcivil.com
Civil Engineering
Public Works
Land Surveying
Project Management
Landscape Architecture

MONTEBANC MANAGEMENT, LLC
PINNACLE AT LIBERTY BAY SUBDIVISION
PRELIMINARY ROAD & UTILITY PLAN
WASHINGTON
CITY OF POULSBORO

JOB NO.: 2090-004-022
DWG. NAME: PP-15
DESIGNED BY:
DRAWN BY:
CHECKED BY:
DATE: 6/20/2025
DATE OF PRINT:


File: \\mms\ENGR\ESM-JOB\2090_004\022\PP-15.dwg
Plotted By: Brandon Locks
Printed: 6/20/2025 3:52 PM

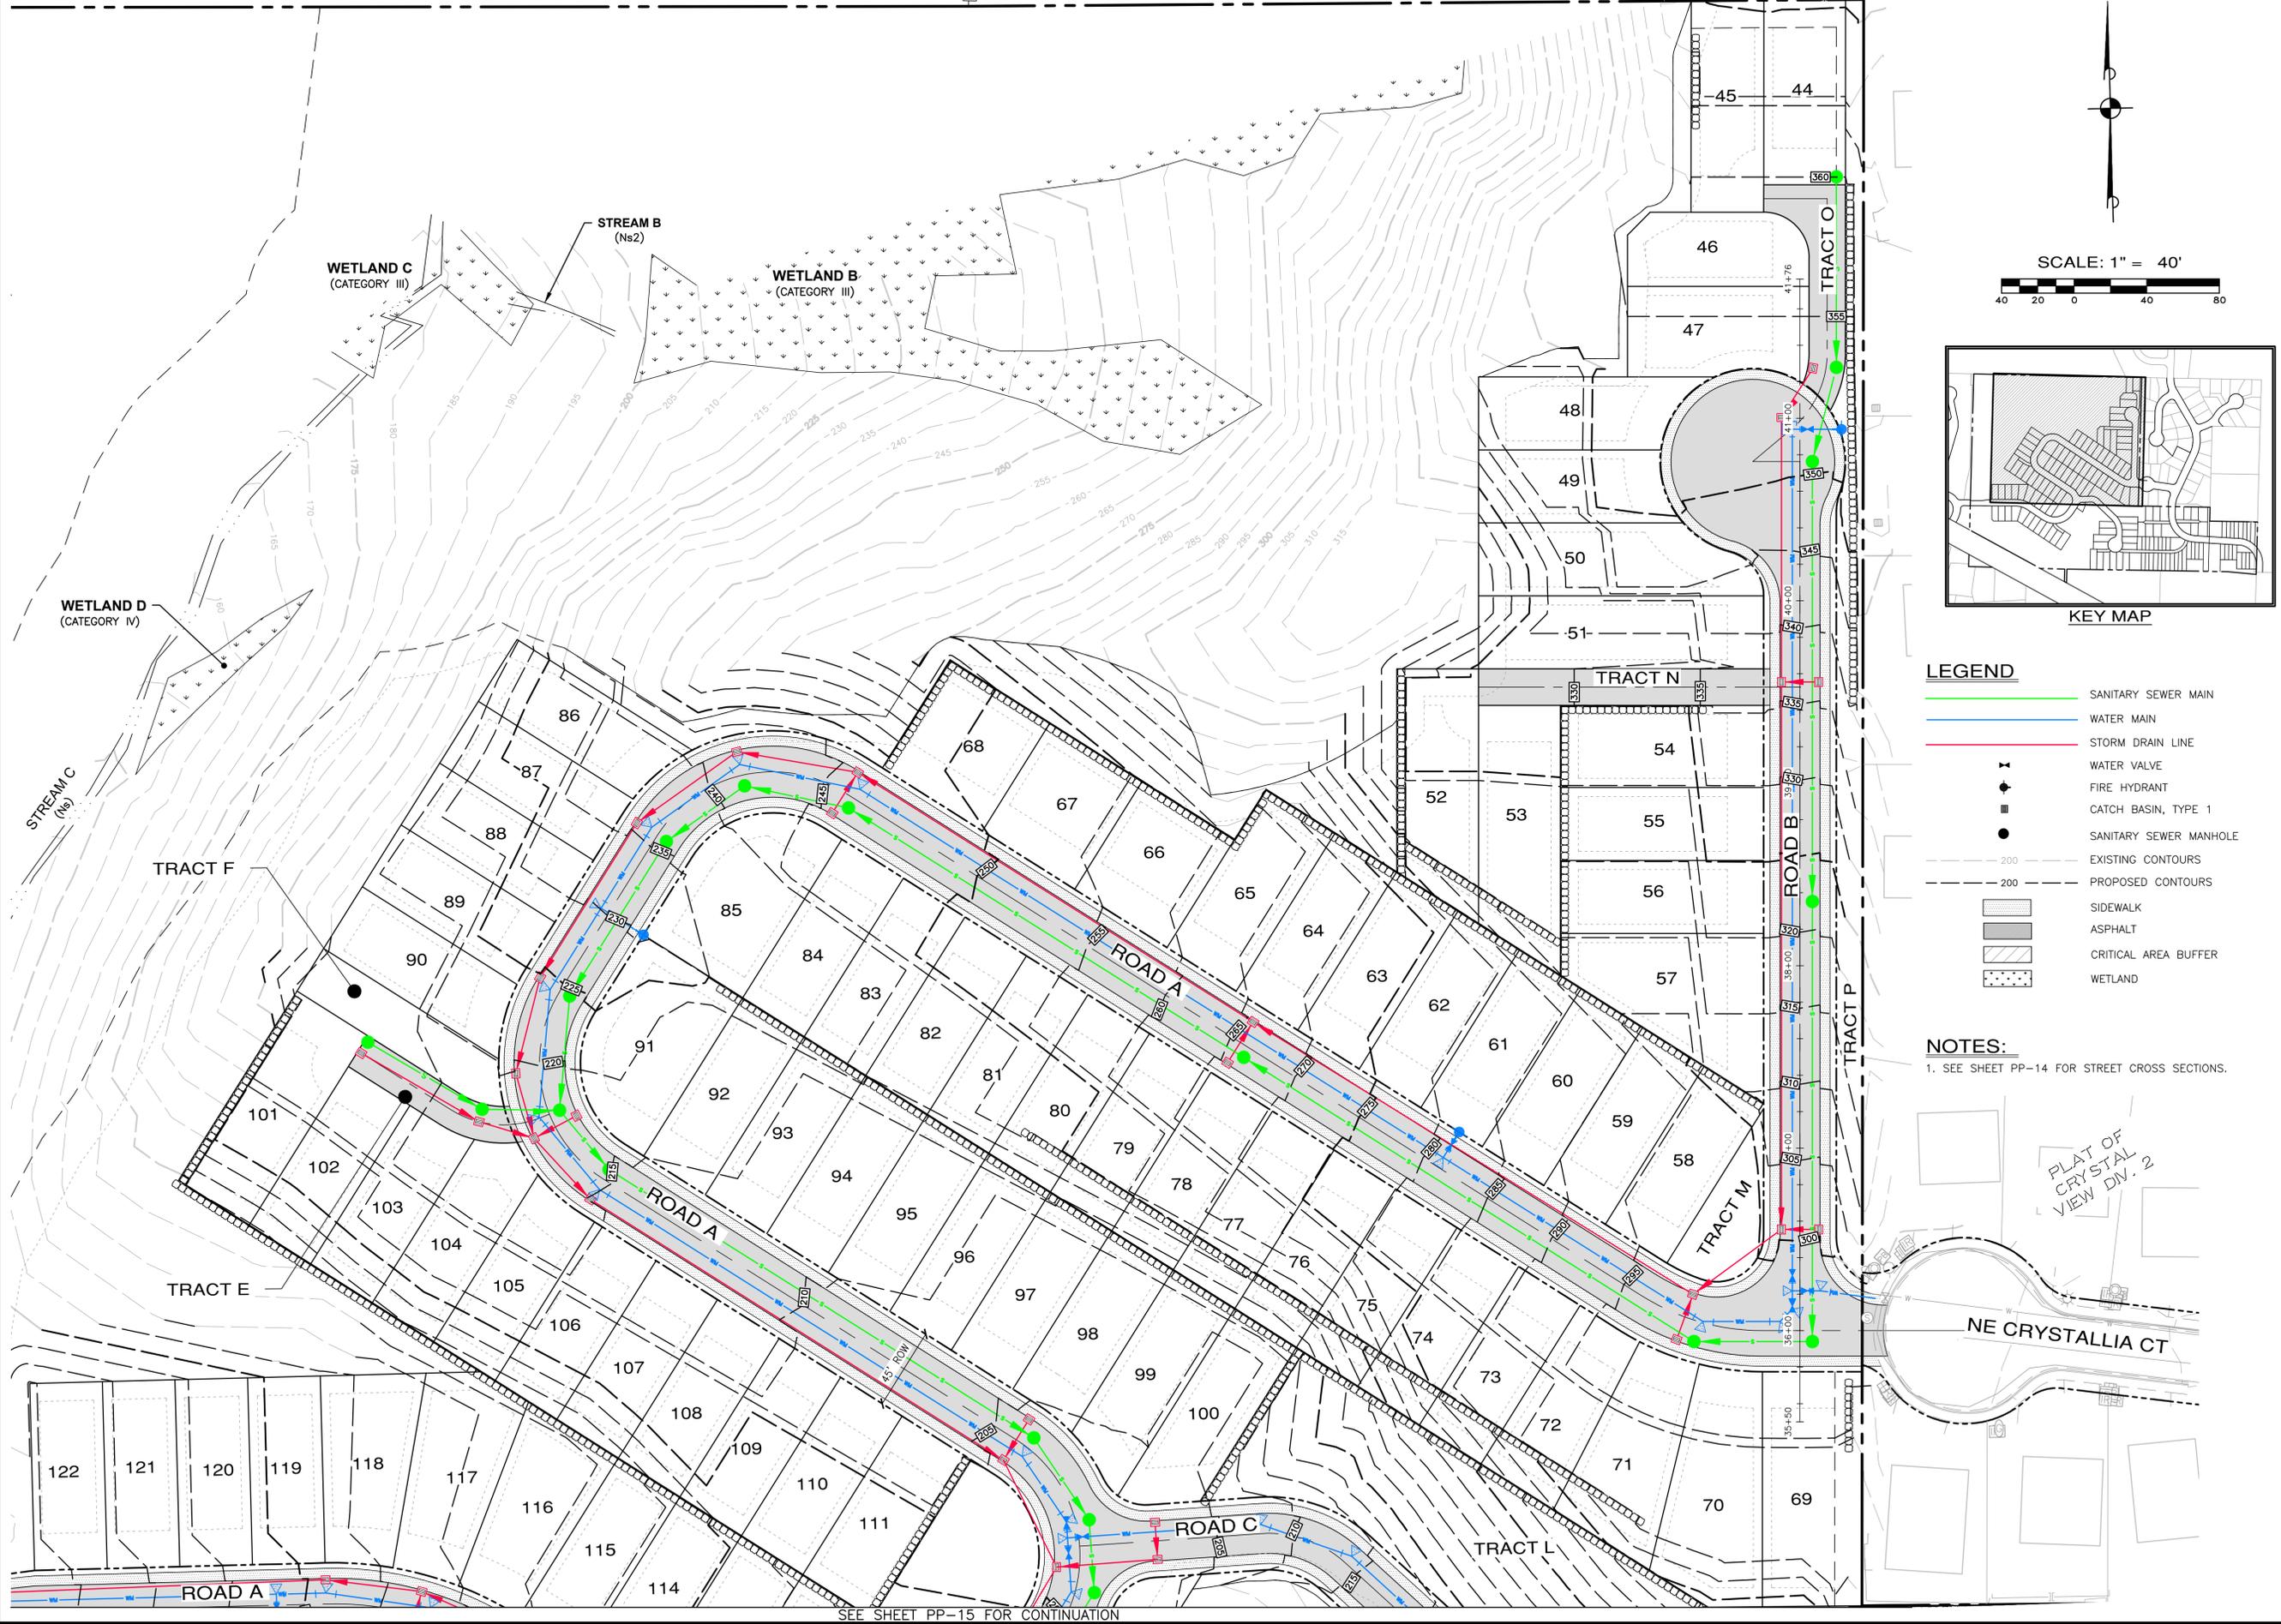

REVISIONS		
NO.	DESCRIPTION/DATE	BY



ESM CONSULTING ENGINEERS, LLC
 33400 8th Ave S, Suite 205
 Federal Way, WA 98003
 www.esmcivil.com
 Civil Engineering | Land Surveying | Project Management | Landscape Architecture
 (206) 838-6113
 (206) 838-6113
 (206) 838-6113

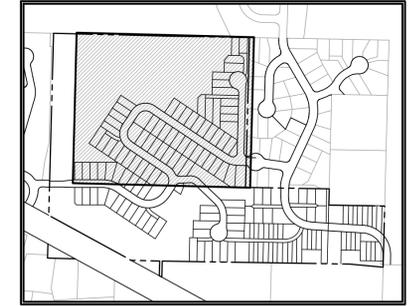

LEGEND

	SANITARY SEWER MAIN
	WATER MAIN
	STORM DRAIN LINE
	WATER VALVE
	FIRE HYDRANT
	CATCH BASIN, TYPE 1
	SANITARY SEWER MANHOLE
	EXISTING CONTOURS
	PROPOSED CONTOURS
	SIDEWALK
	ASPHALT
	CRITICAL AREA BUFFER
	WETLAND

NOTES:
 1. SEE SHEET PP-14 FOR STREET CROSS SECTIONS.

File: \\smc\ENGR\ESM-JOB\232601-4-008\PP-16.dwg
 Plotted By: Brandon Loucks
 Date: 6/20/2025 4:46 PM

SEE SHEET PP-15 FOR CONTINUATION

MONTEBANC MANAGEMENT, LLC
PINNACLE AT LIBERTY BAY SUBDIVISION
 PRELIMINARY ROAD & UTILITY PLAN
 WASHINGTON
 CITY OF POULLSBORO

JOB NO.:	2090-004-022
DWG. NAME:	PP-16
DESIGNED BY:	
DRAWN BY:	
CHECKED BY:	
DATE:	6/20/2025
DATE OF PRINT:	

PP-16
 16 OF 26 SHEETS

A PORTION OF THE SE 1/4 OF SECTION 23, TWP. 26 N., RGE. 1 E., WM



SCALE: 1" = 20'
 20 10 0 20 40
 CONTOUR INTERVAL = 5'


- LEGEND**
- 200- EXISTING CONTOUR
 - 200- PROPOSED CONTOUR
 - EDGE OF GRADING
 - - - - WETLAND BUFFER
 - ○ ○ ○ CYCLONE FENCE

REVISIONS		
NO.	DESCRIPTION/DATE	BY

ESM CONSULTING ENGINEERS, LLC
 33400 8th Ave S, Suite 205
 Federal Way, WA 98003
 www.esmcivil.com
 Civil Engineering | Land Surveying | Project Management
 Public Works | Landscape Architecture



MONTEBANC MANAGEMENT, LLC
PINNACLE AT LIBERTY BAY SUBDIVISION
 PRELIMINARY POND LAYOUT
 WASHINGTON
 CITY OF POULSBORO

JOB NO.:	2090-004-022
DWG. NAME:	PP-17
DESIGNED BY:	
DRAWN BY:	
CHECKED BY:	
DATE:	6/20/2025
DATE OF PRINT:	
PP-17	
17 OF 26 SHEETS	

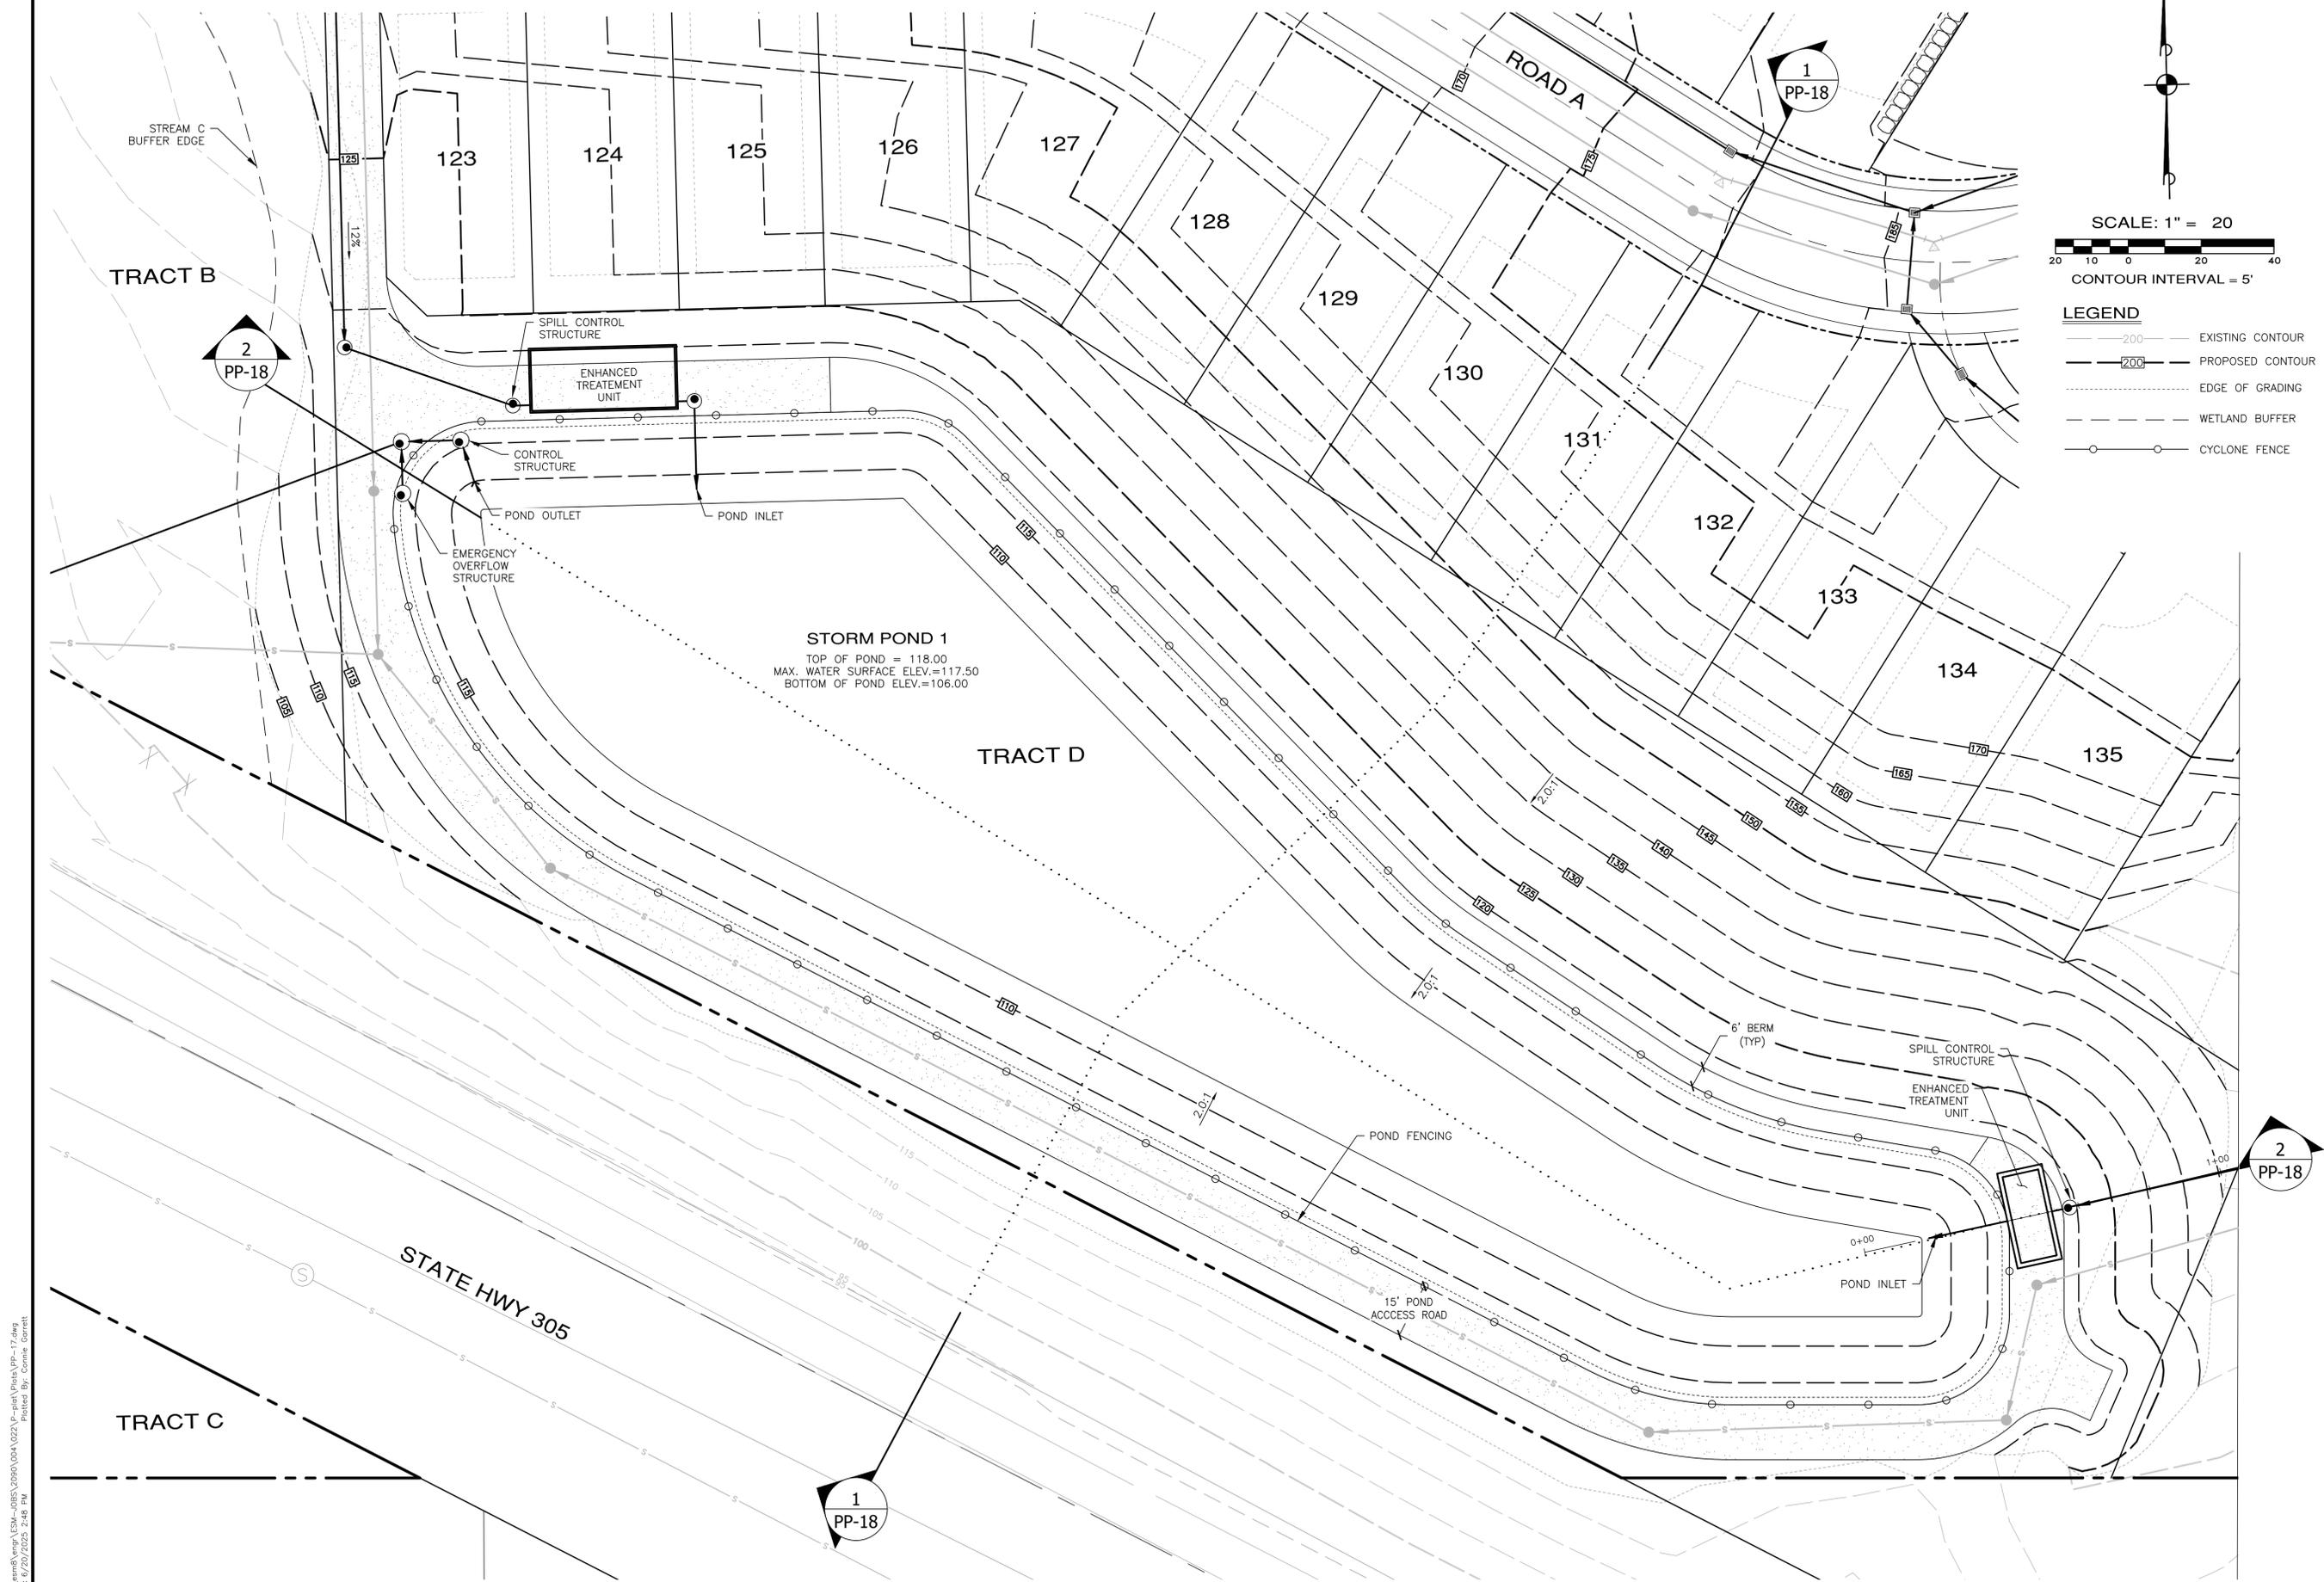

File: \\smc\eng\ESM-0053\2090\004\022\PP-17.dwg
 Plotted By: Corrie Barrett
 Plotted: 6/20/2025 2:48 PM

A PORTION OF THE SE 1/4 OF SECTION 23, TWP. 26 N., RGE. 1 E., WM

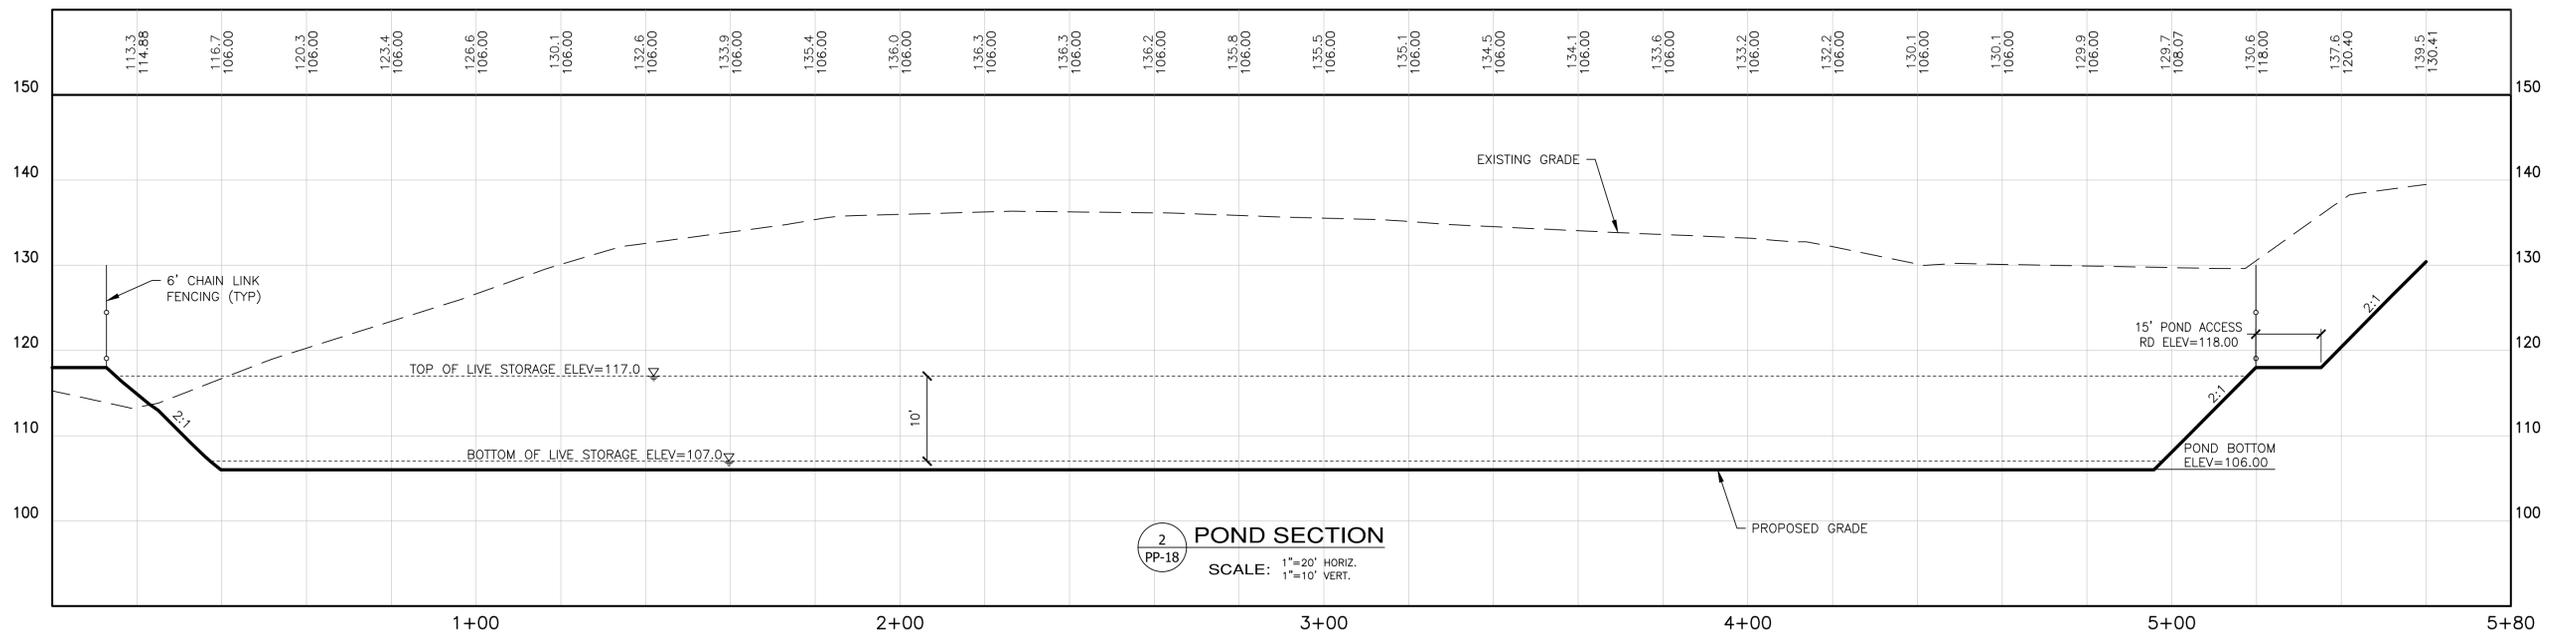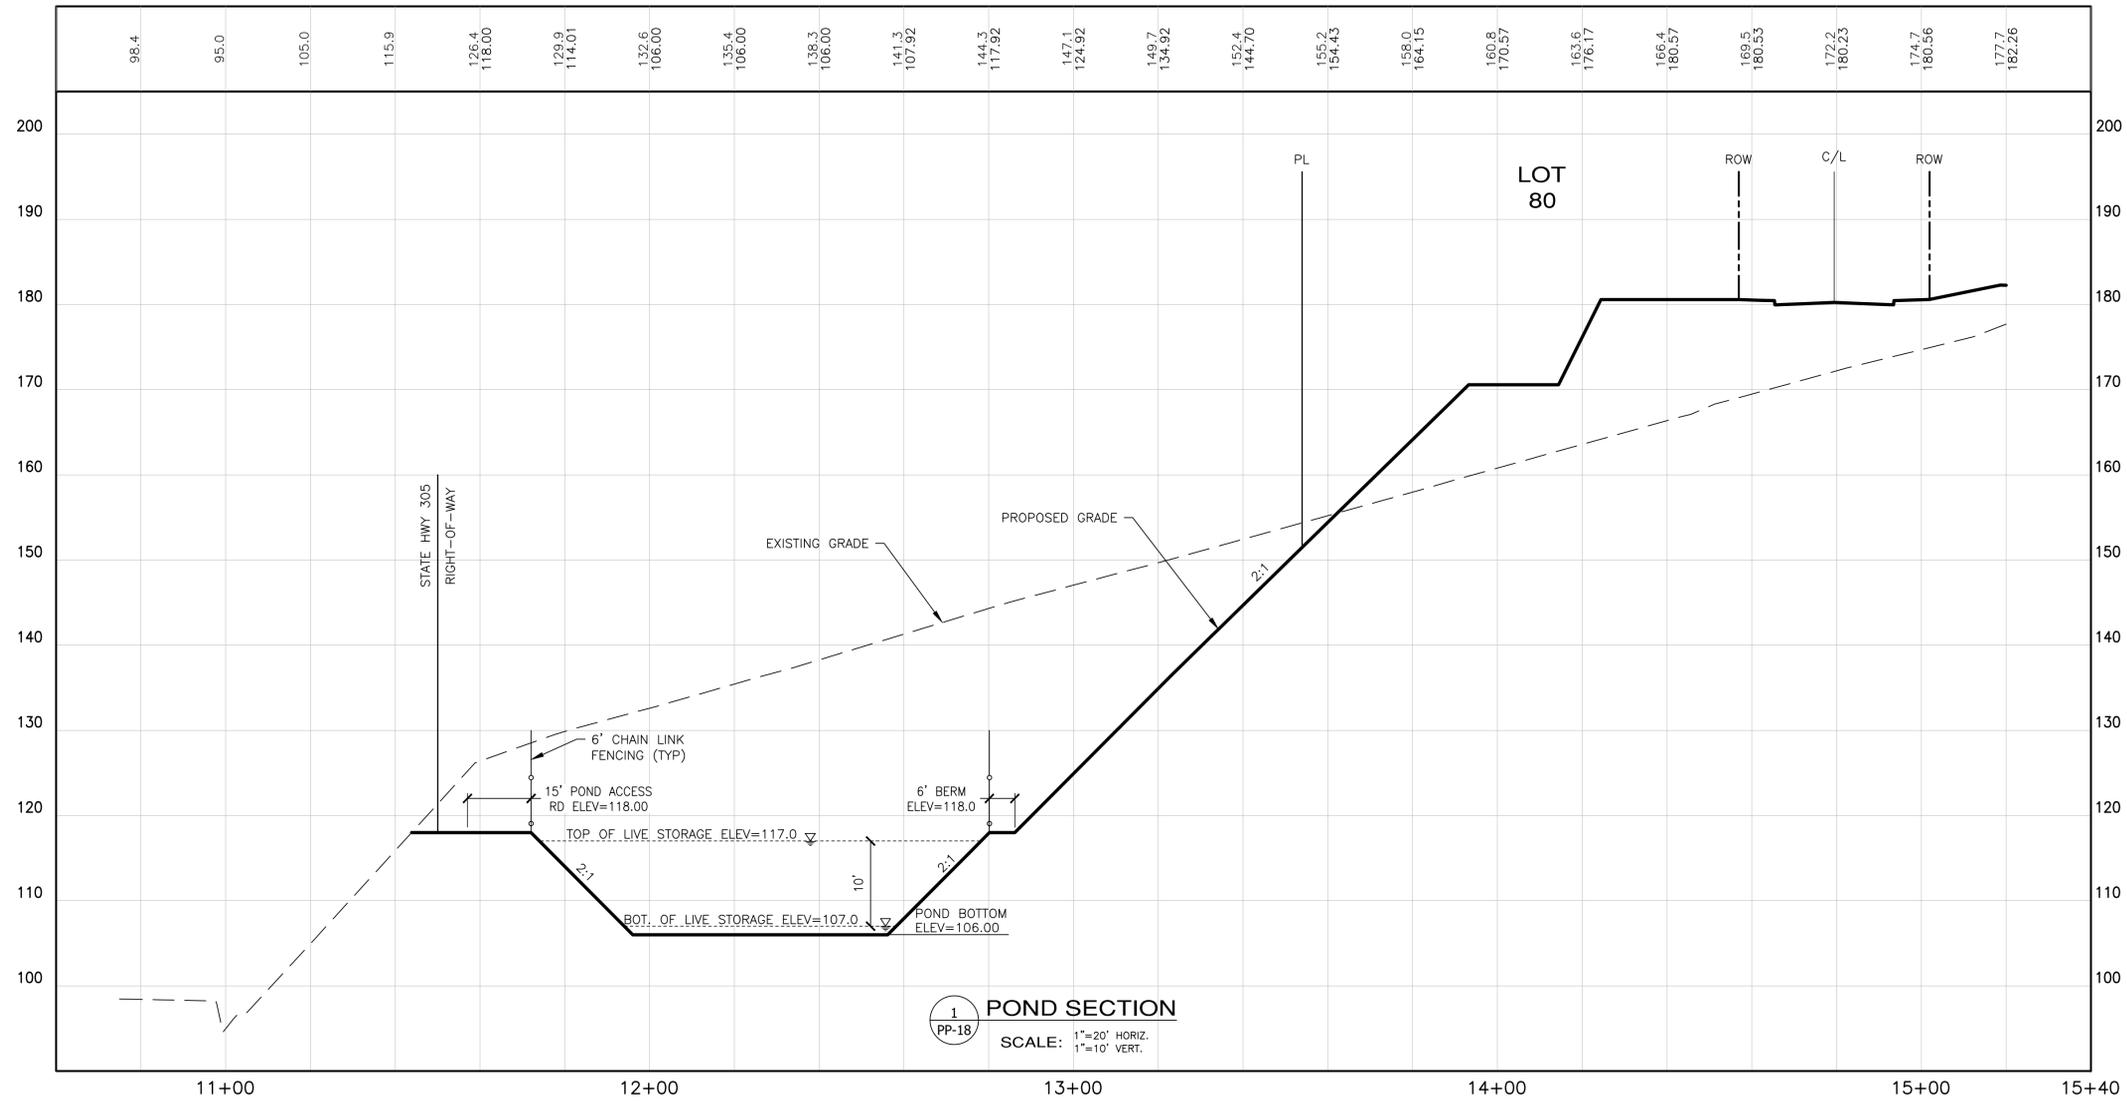

REVISIONS		
NO.	DESCRIPTION/DATE	BY

ESM CONSULTING ENGINEERS, LLC
33400 8th Ave S, Suite 205
Federal Way, WA 98003
www.esmcivil.com

Professional Engineer
Civil Engineering
Public Works

Land Surveying
Project Management
Landscape Architecture




06/20/2025

MONTEBANC MANAGEMENT, LLC
PINNACLE AT LIBERTY BAY SUBDIVISION
PRELIMINARY POND SECTIONS
WASHINGTON
CITY OF POULLSBORO


JOB NO.:	2090-004-022
DWG. NAME:	PP-18
DESIGNED BY:	
DRAWN BY:	
CHECKED BY:	
DATE:	6/20/2025
DATE OF PRINT:	

File: \\smc\ENGR\ESM-JOB\2090\004\022\PP-18.dwg
Plotted By: Brandon Loucks
6/20/2025 4:03 PM

A PORTION OF THE SE 1/4 OF SECTION 23, TWP. 26 N., RGE. 1 E., WM

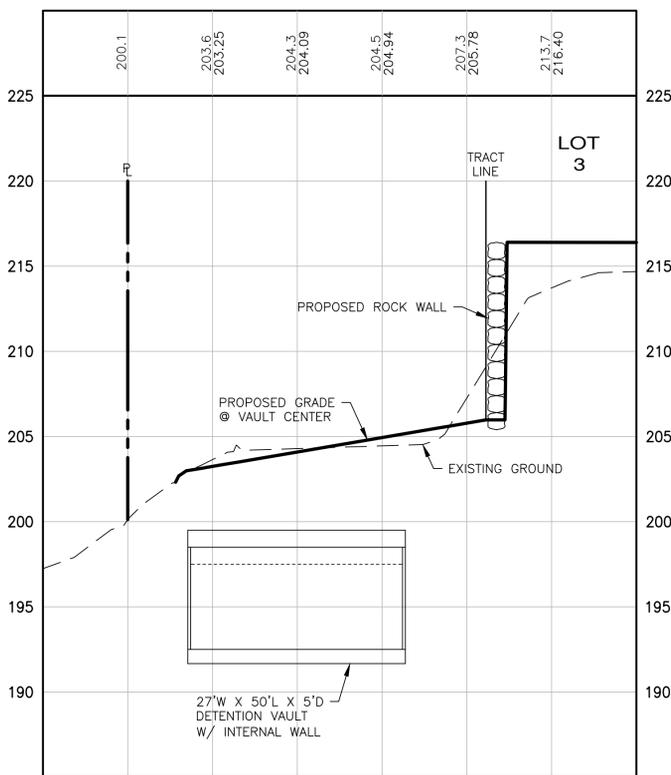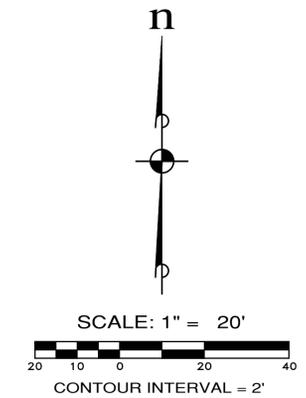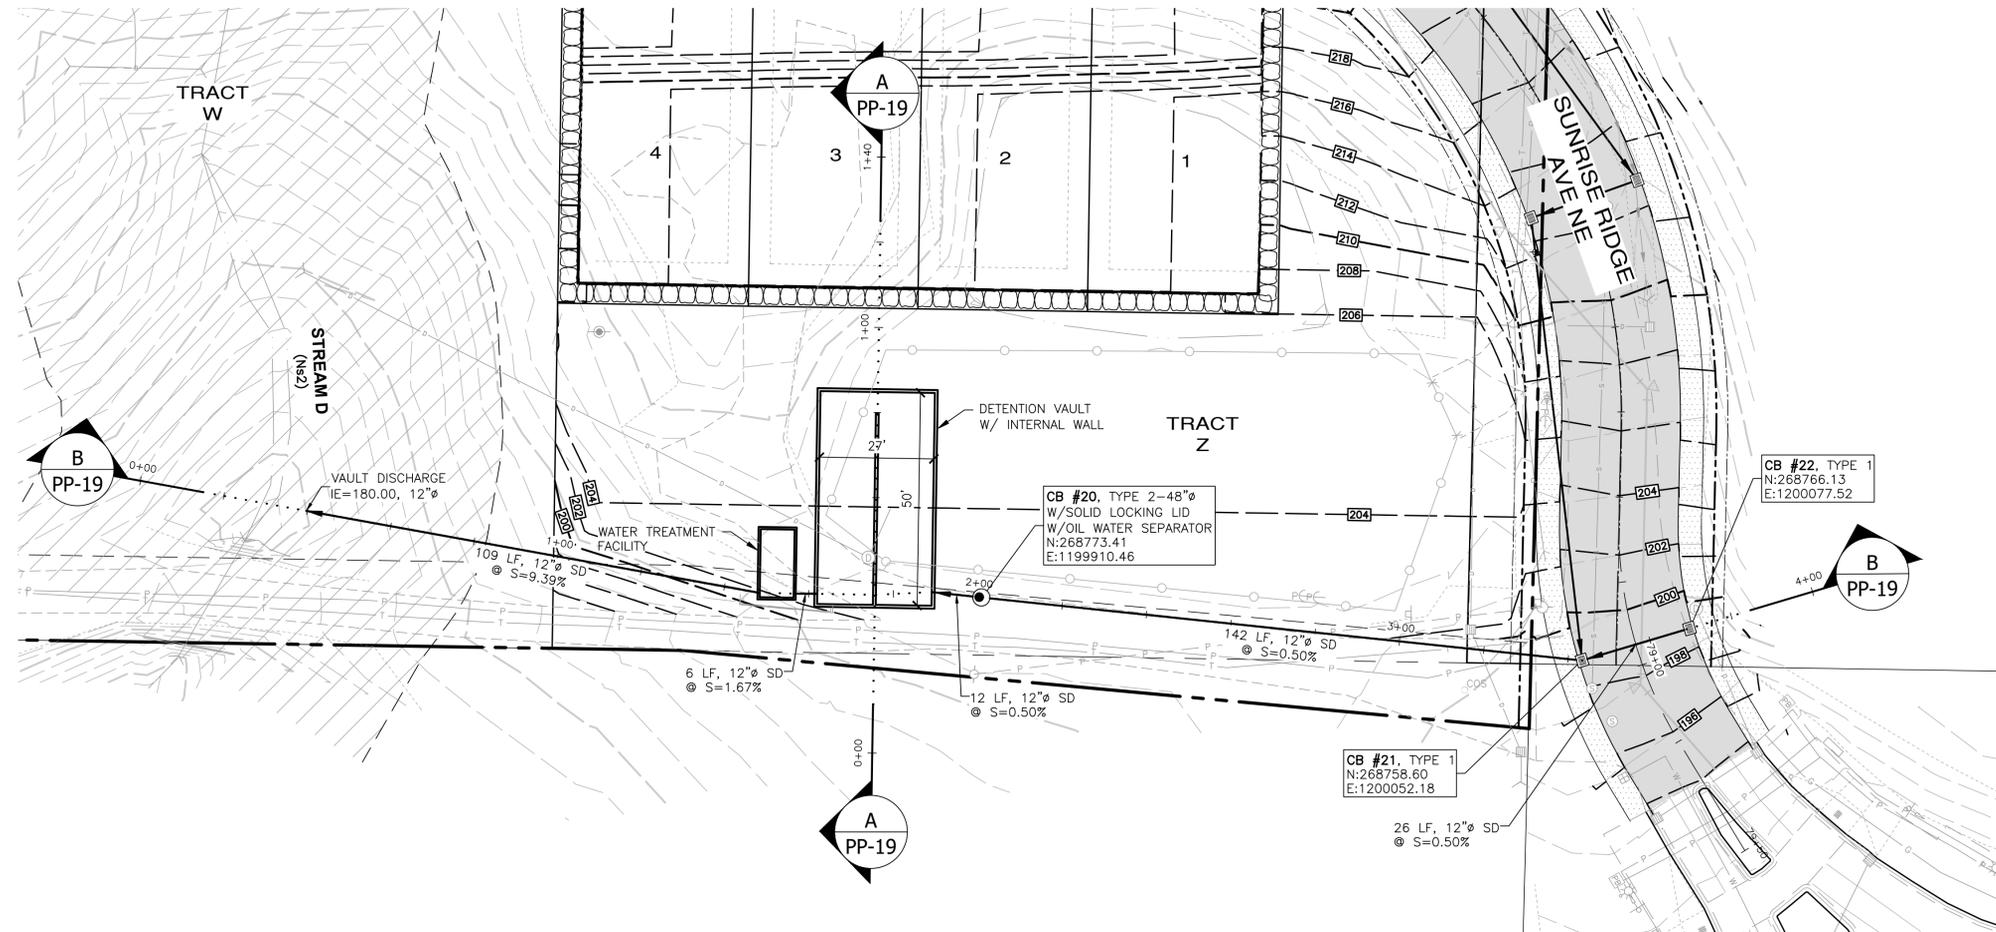

VAULT CROSS SECTION A-A
SCALE: 1"=20' HORIZ.
1"=5' VERT.

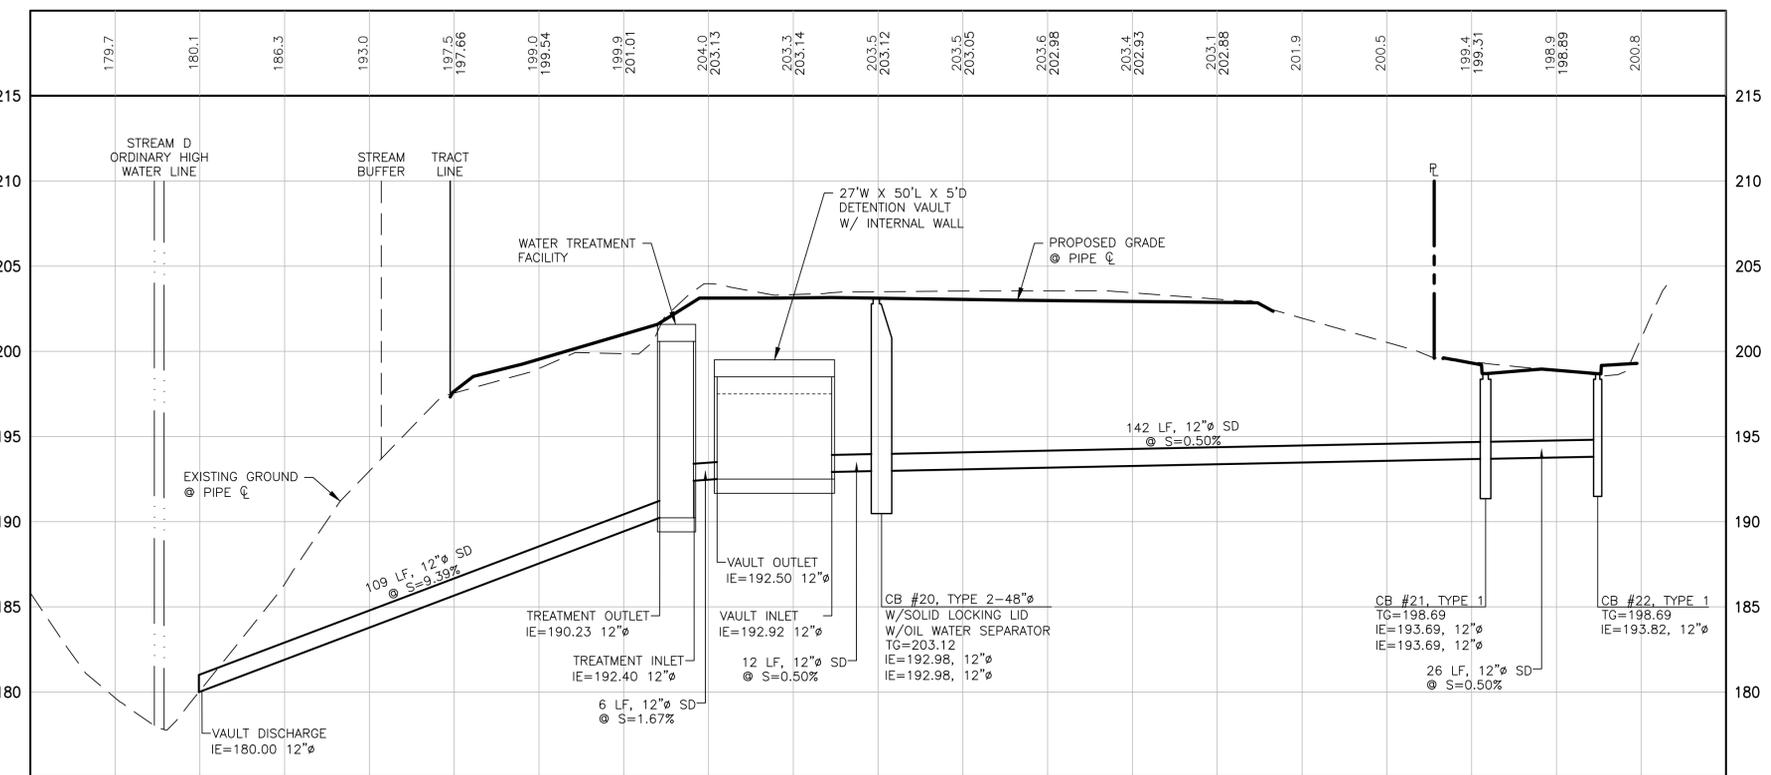

VAULT CROSS SECTION B-B
SCALE: 1"=20' HORIZ.
1"=5' VERT.

File: \\smc\ENR\ESM-0085\2090\004\022\PP-19.dwg
Printed: 6/20/2025 2:55 PM
Plotted By: Brandon Loucks

REVISIONS		
NO.	DESCRIPTION/DATE	BY

BRANDON MICHAEL LOUCKS
PROFESSIONAL ENGINEER
06/20/2025

ESM CONSULTING ENGINEERS, LLC
33400 8th Ave S, Suite 205
Federal Way, WA 98003
www.esmcivil.com

Civil Engineering
Public Works


 

Land Planning
Landscape Architecture

MONTEBANC MANAGEMENT, LLC
Pinnacle at Liberty Bay Subdivision
CITY OF POULSBORO
WASHINGTON

PRELIMINARY VAULT SECTIONS

JOB NO.: 2090-004-022
DWG. NAME: PP-19
DESIGNED BY:
DRAWN BY:
CHECKED BY:
DATE: 6/20/2025
DATE OF PRINT:
PP-19
19 OF 26 SHEETS

A PORTION OF THE SE 1/4 OF SECTION 23, TWP. 26 N., RGE. 1 E., WM

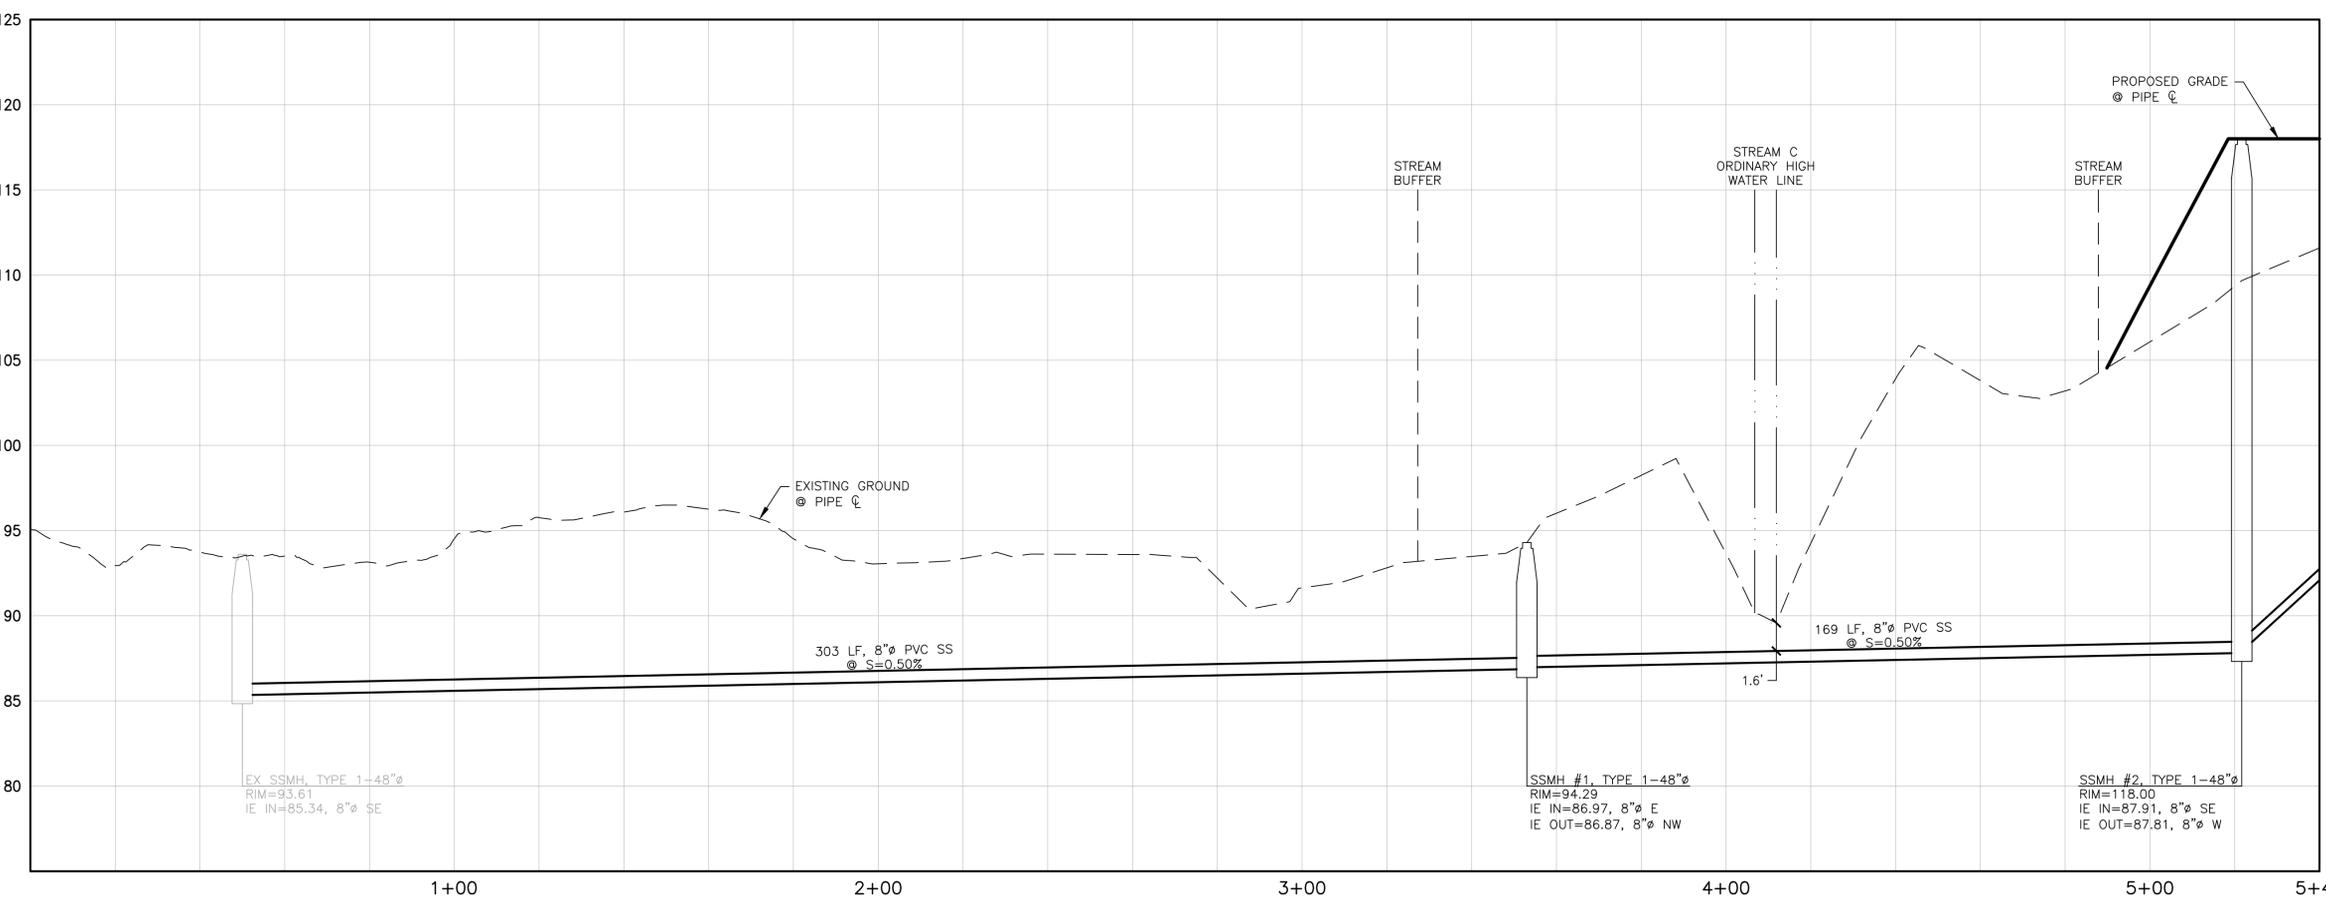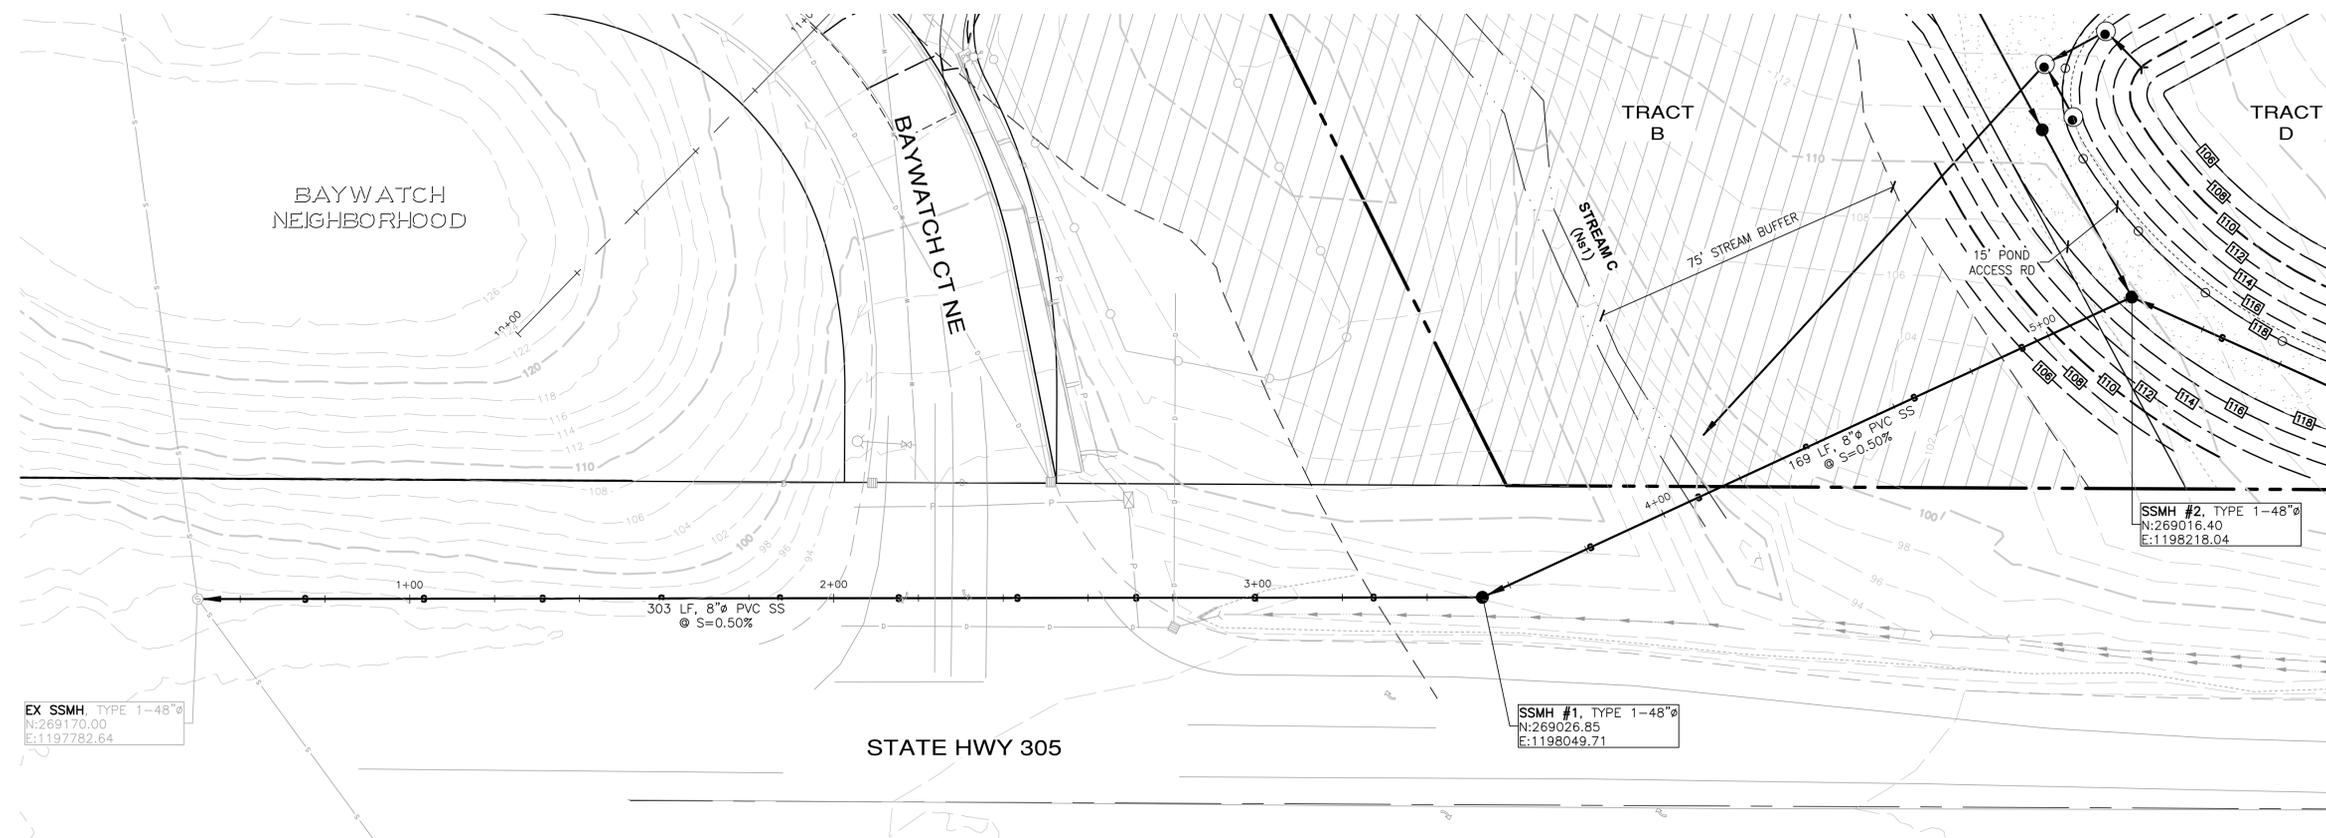

CREEK C SEWER CROSSING
SCALE: 1"=20' HORIZ.
1"=5' VERT.

REVISIONS		
NO.	DESCRIPTION/DATE	BY

ESM CONSULTING ENGINEERS, LLC
 33400 8th Ave S, Suite 205
 Federal Way, WA 98003
 www.esmcivil.com




Professional Engineer License No. 5008
 State of Washington
 Civil Engineering
 Land Surveying
 Project Management
 Land Planning
 Landscape Architecture

MONTEBANC MANAGEMENT, LLC
PINNACLE AT LIBERTY BAY SUBDIVISION
 CITY OF POUSETT SITE SEWER CONNECTION/CROSSING PLAN & PROFILE WASHINGTON

JOB NO.:	2090-004-022
DWG. NAME:	PP-20
DESIGNED BY:	
DRAWN BY:	
CHECKED BY:	
DATE:	6/20/2025
DATE OF PRINT:	

File: \\smc\eng\ESM-JOB\2090\004\PP-20.dwg
 Plotted: 6/20/2025 2:53 PM
 Plotted By: Corrie Corrett

A PORTION OF THE SE 1/4 OF SECTION 23, TWP. 26 N., RGE. 1 E., WM

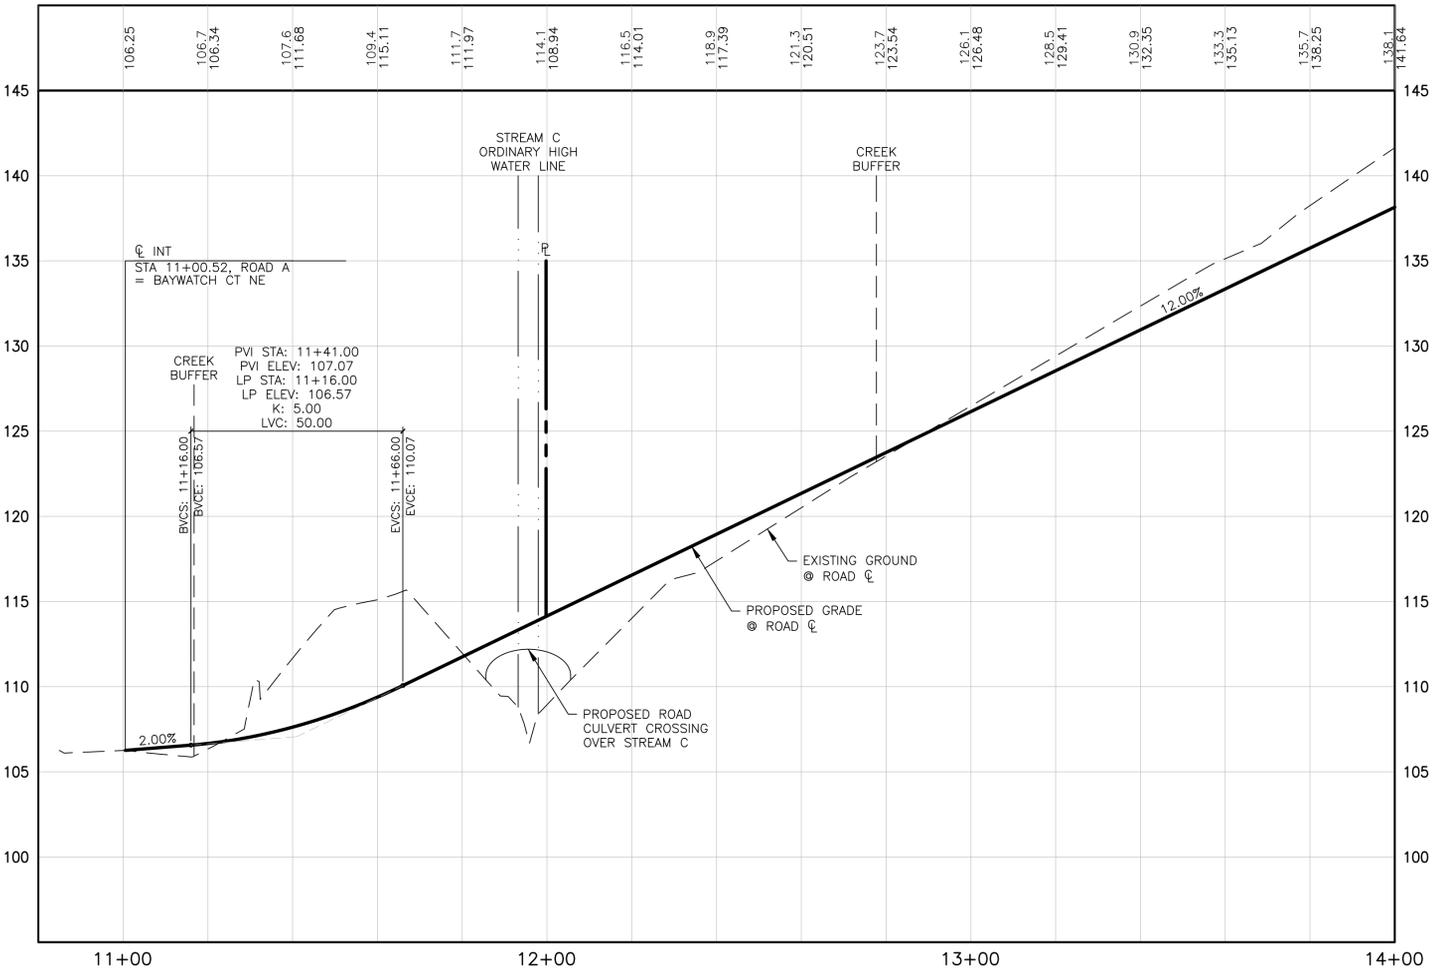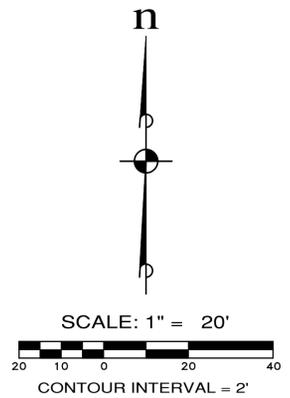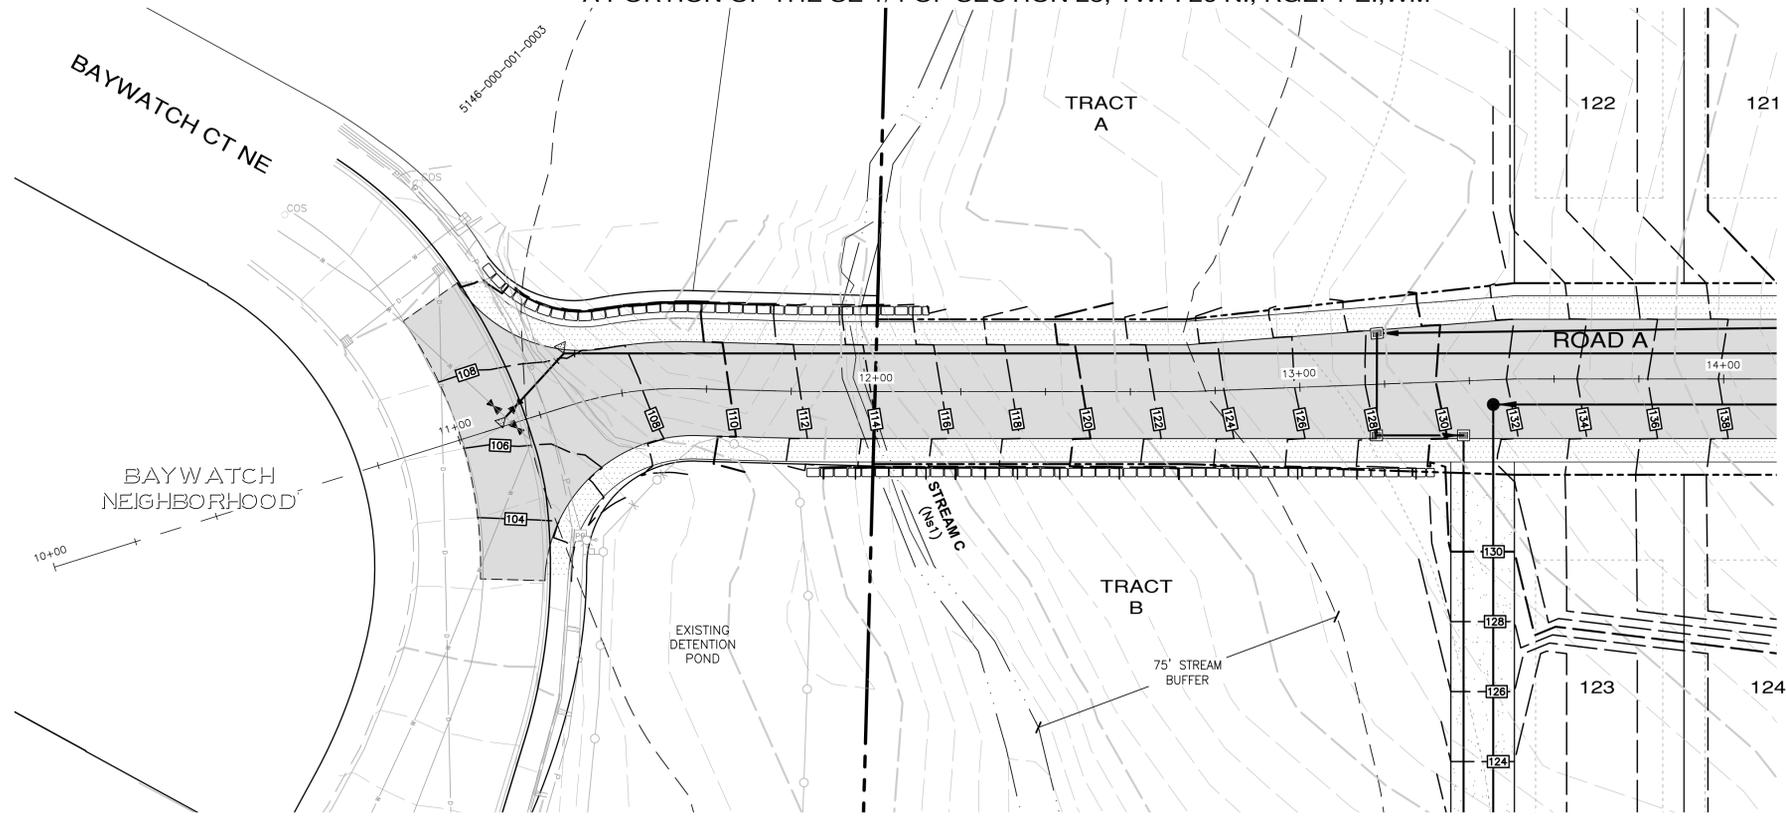

CREEK C CROSSING
SCALE: 1"=20' HORIZ.
1"=5' VERT.

REVISIONS		
NO.	DESCRIPTION/DATE	BY

ESM CONSULTING ENGINEERS, LLC
 33400 8th Ave S, Suite 205
 Federal Way, WA 98003
 www.esmcivil.com
 Civil Engineering | Land Surveying | Project Management | Landscape Architecture
 (253) 838-6113
 (253) 837-9900
 06/20/2025

MONTEBANC MANAGEMENT, LLC
PINNACLE AT LIBERTY BAY SUBDIVISION
 CITY OF POULSBORO | STREAM C CROSSING PLAN & PROFILE | WASHINGTON

JOB NO.:	2090-004-022
DWG. NAME:	PP-22
DESIGNED BY:	
DRAWN BY:	
CHECKED BY:	
DATE:	6/20/2025
DATE OF PRINT:	

File: \\smc\eng\ESM-0085\0085\004\022\PP-22.dwg
 Plotted: 6/20/2025 2:56 PM
 Plotted By: Corrie Corrett

